
PROJ. REFERENCE NO. SHEET NO.

U-4737
TCP-6

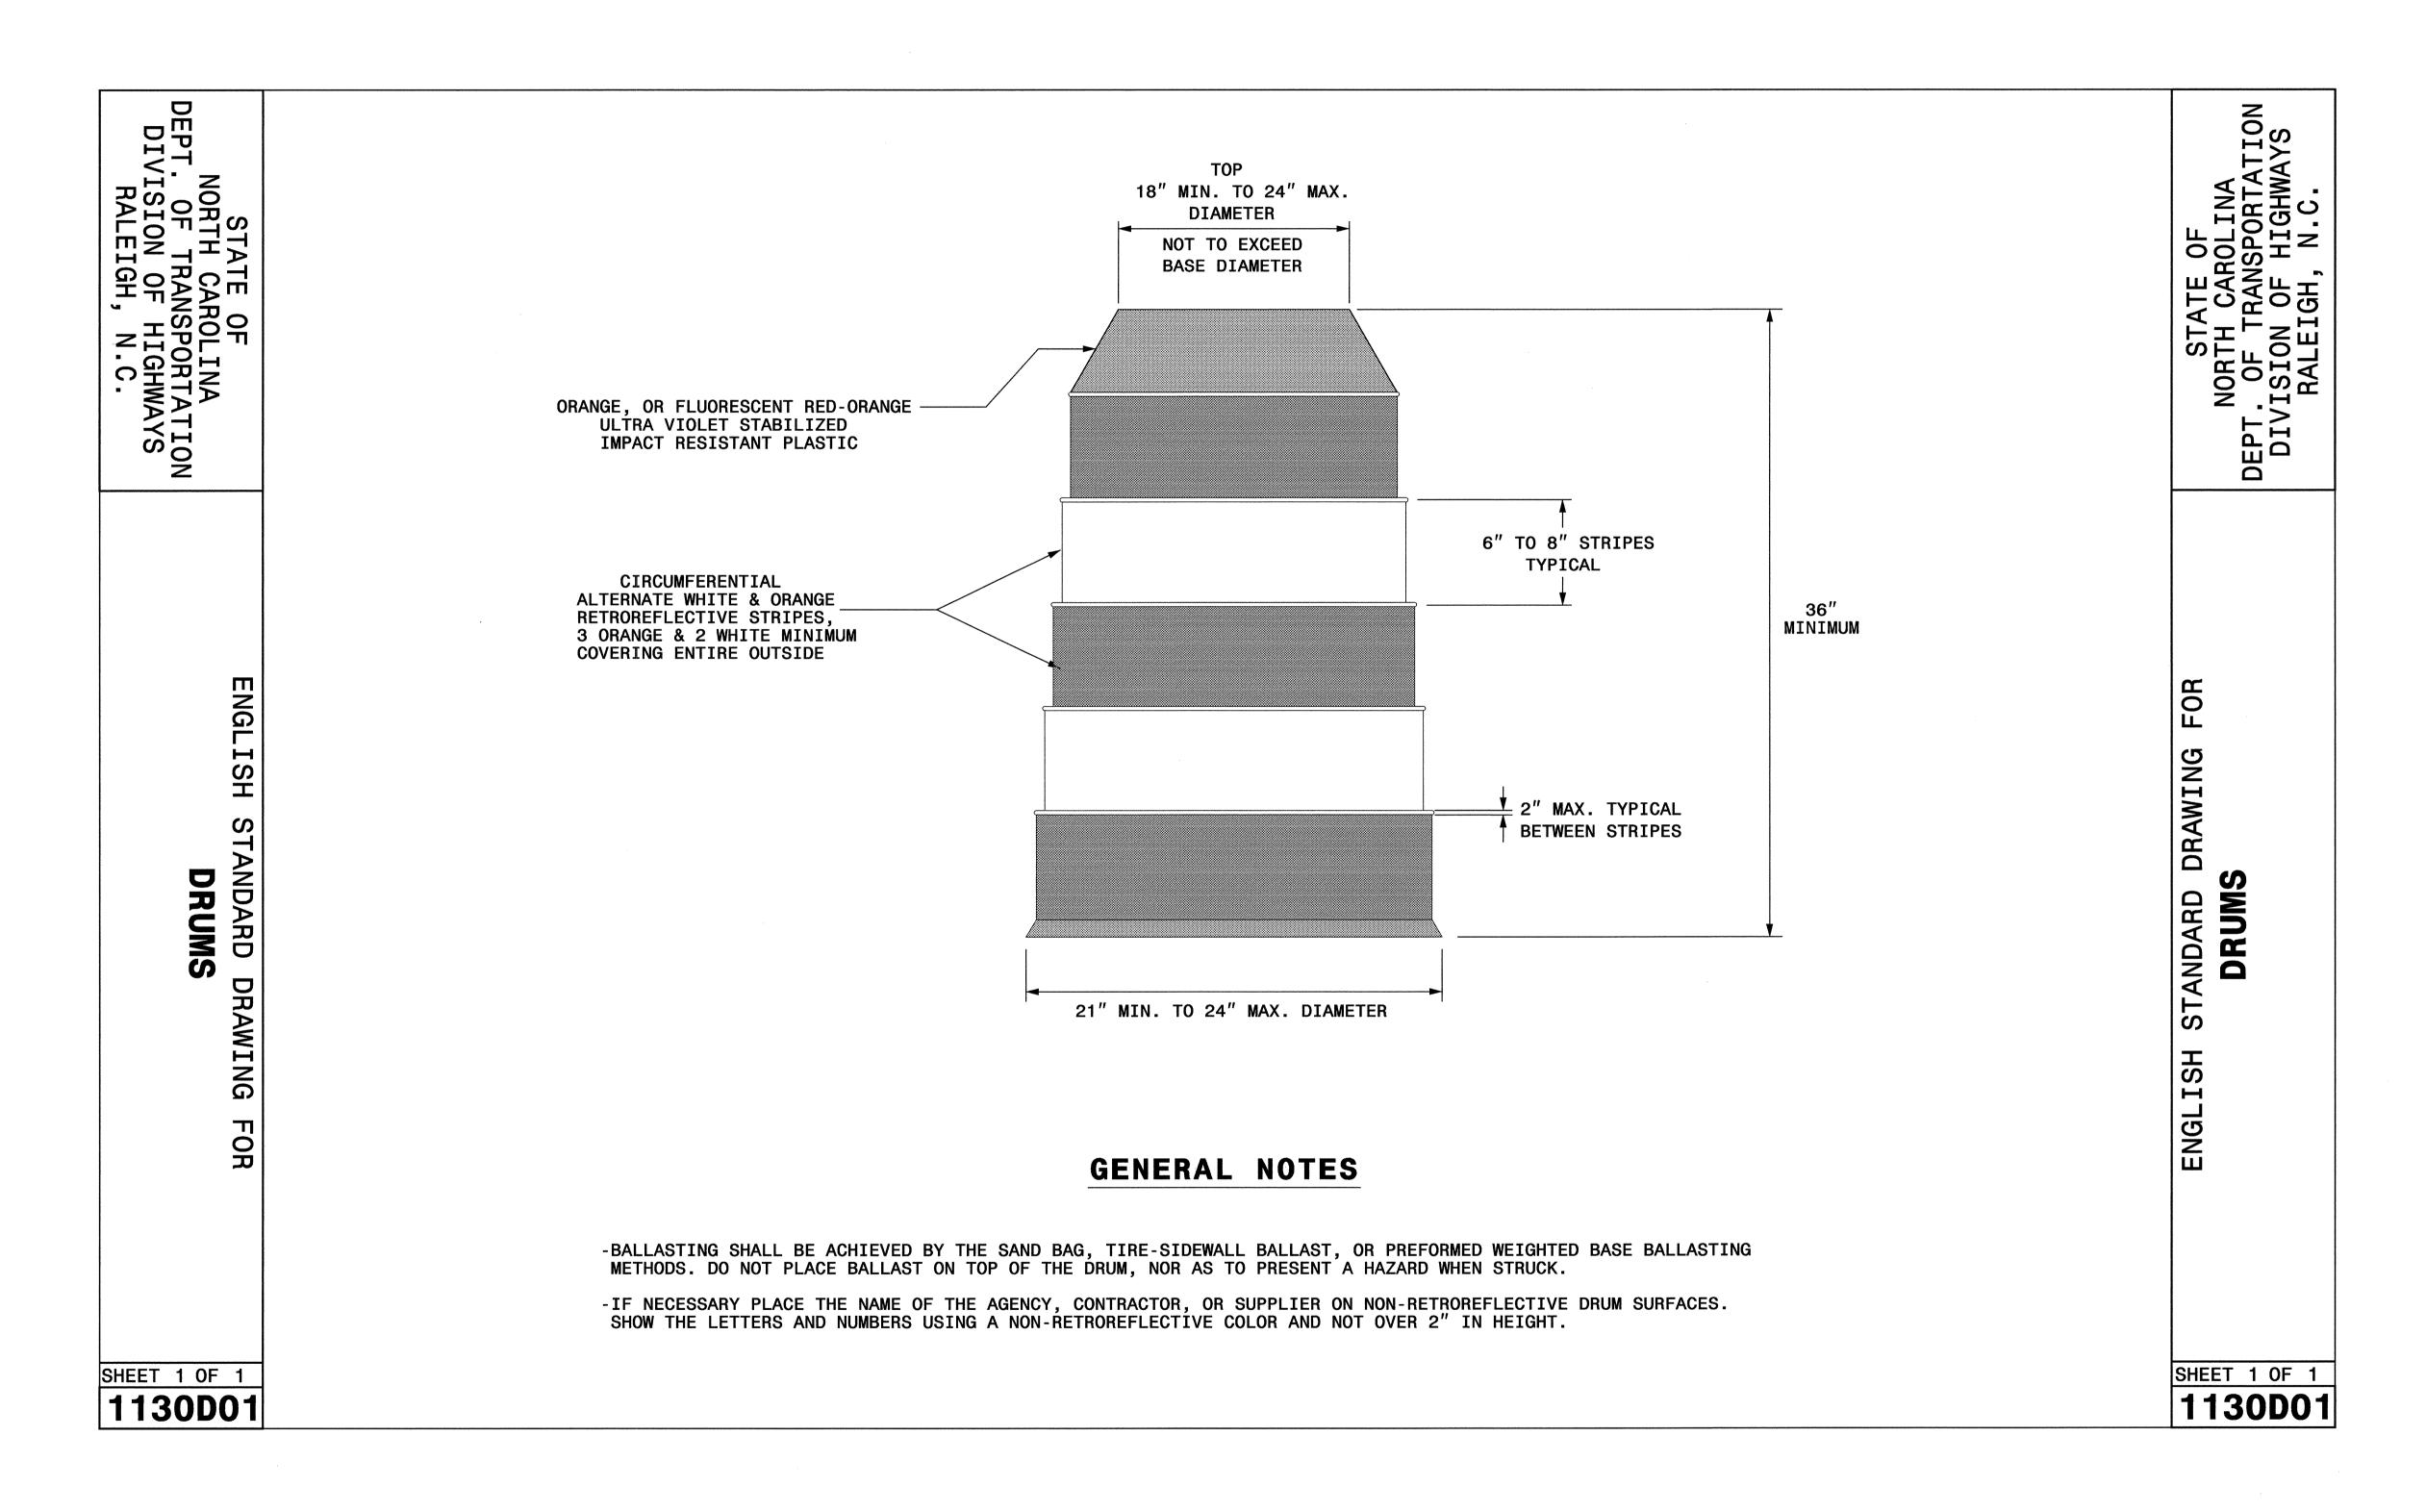

22-MAR-2005 10:40 D:\DDC\PROJECTS\PITT\ARLINGTON BLVD\Arlington with left turn\arl migckson AT

REPLACEMENT DETAIL FOR

RSD 1130.01

SEAL 27818

SEAL 27818

SEAL 27818

REVISIONS

REVISIONS

CADD FILE

CARD BY: MMM

REVIEWED BY: MMM

REVIEWED BY: MMM