


8/17/99

I4-MAR-2006 16:08
st:\specdes\ut\1135\1135.dwg
shah\ddc.and.wbs\wbs_37631_ashboro_r\proj\phco\proj\pah\salisbury.ut.uc9_s013_wbs_37631_ashboro.dgn

MATCH LINE STA 64+00 SEE SHEET UC-8

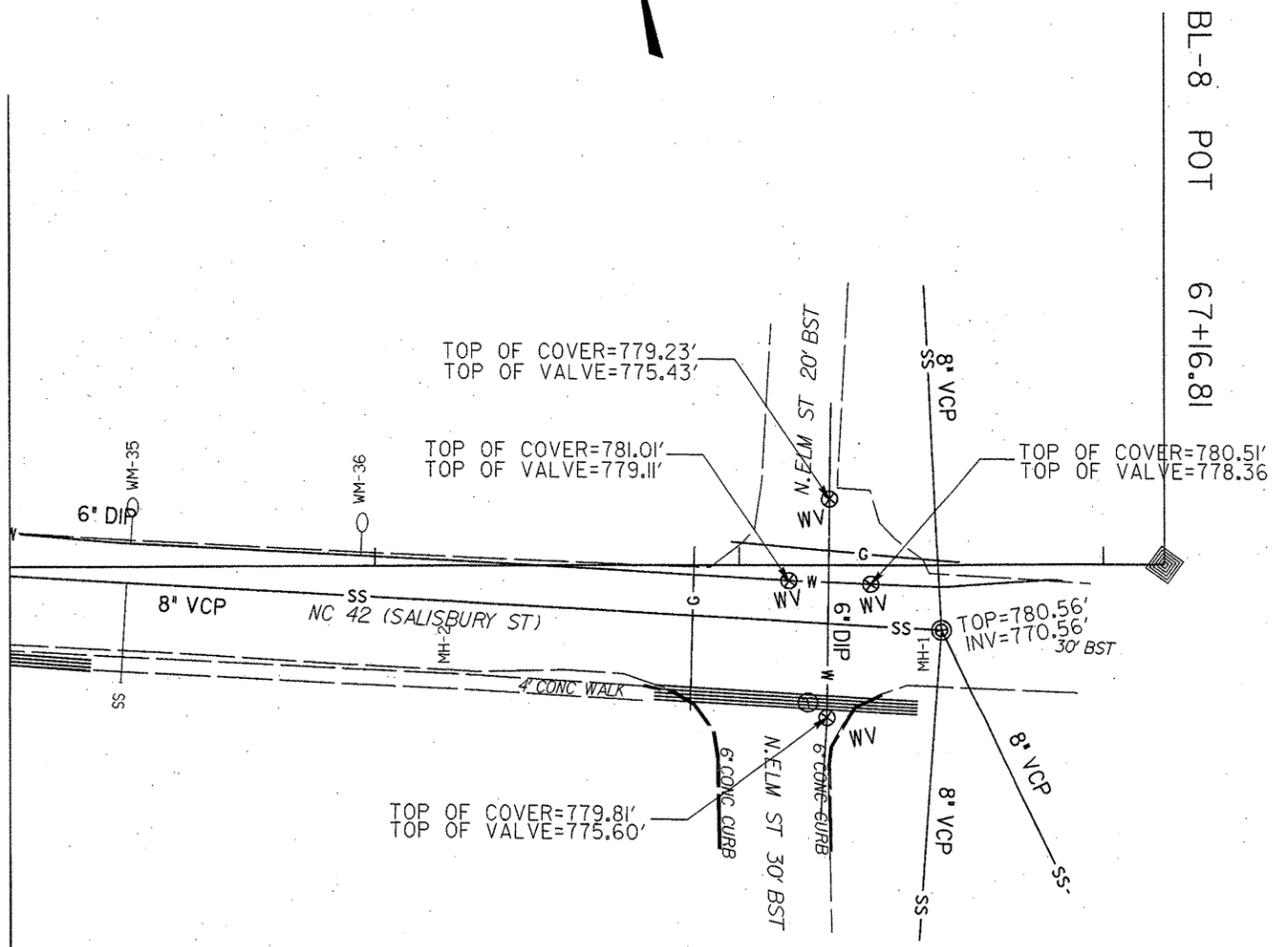

BL-8 POT 67+16.81

SCALE: 1" = 25'

PROJECT REFERENCE NO.	37631	SHEET NO.	UC-9
DESIGNED BY:	NSH		
DRAWN BY:	NSH		
CHECKED BY:	JSM		
APPROVED BY:	JSM		
REVISED:			
NORTH CAROLINA DEPARTMENT OF TRANSPORTATION		UTILITY CONSTRUCTION PLANS ONLY	
DESIGN SERVICES UNIT		PHONE: (919) 250-4128	
		FAX: (919) 250-4119	

UTILITY CONSTRUCTION

