


FIRE ALARM RISER DIAGRAM NO SCALE

POWERING CONTROL PANEL. BREAKER SHALL BE COMPATIBLE WITH EXISTING PANEL. BREAKER AIC RATING SHALL MATCH EXISTING.

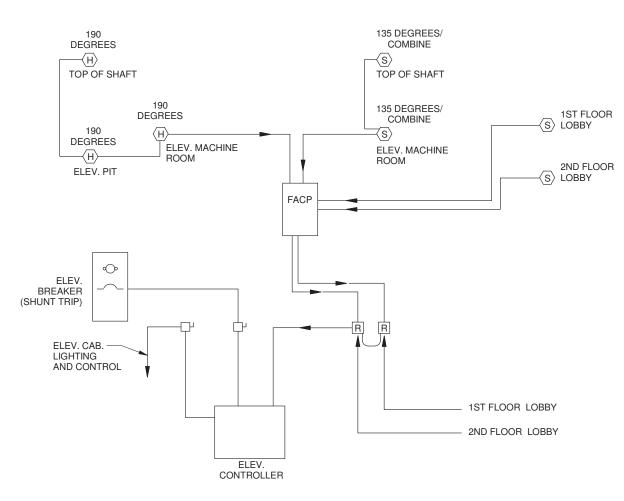


3 ELEVATOR RECALL AND DETECTION DETAIL 1)
NO SCALE

GENERAL PLAN NOTES:

PROVIDE PLENUM RATED CABLE ABOVE CEILINGS. PROVIDE CABLE IN CONDUIT IN ALL EXPOSED AREAS.


DRAWING NOTES:

(1) COORDINATE EXACT REQUIREMENTS WITH ELEVATOR MANUFACTURER.

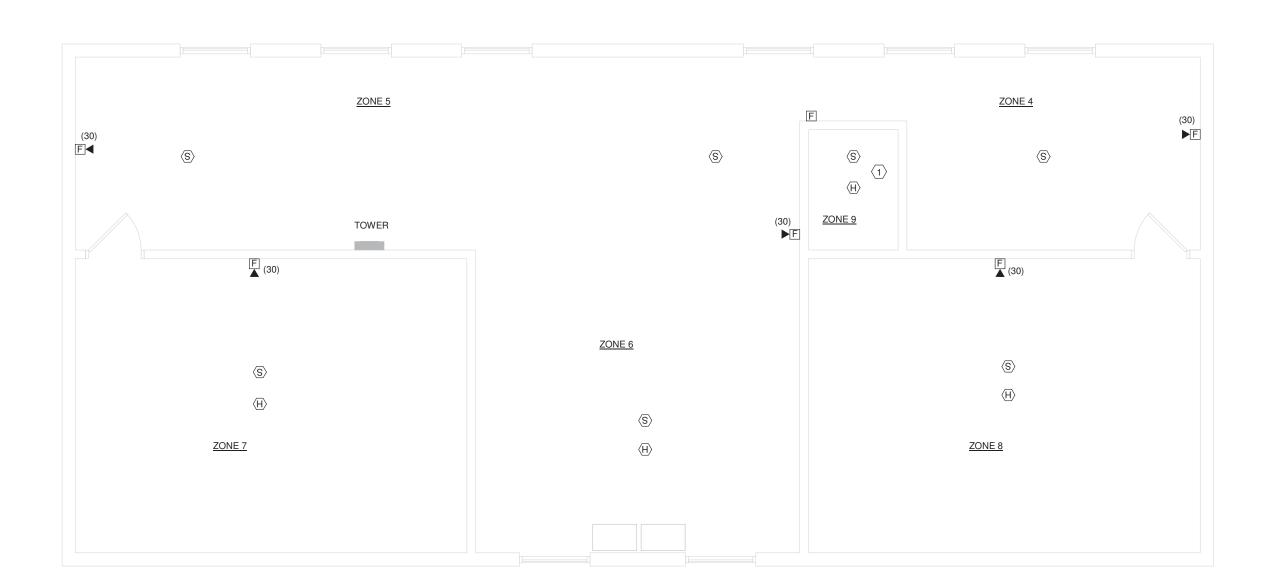

TOWER PLAN



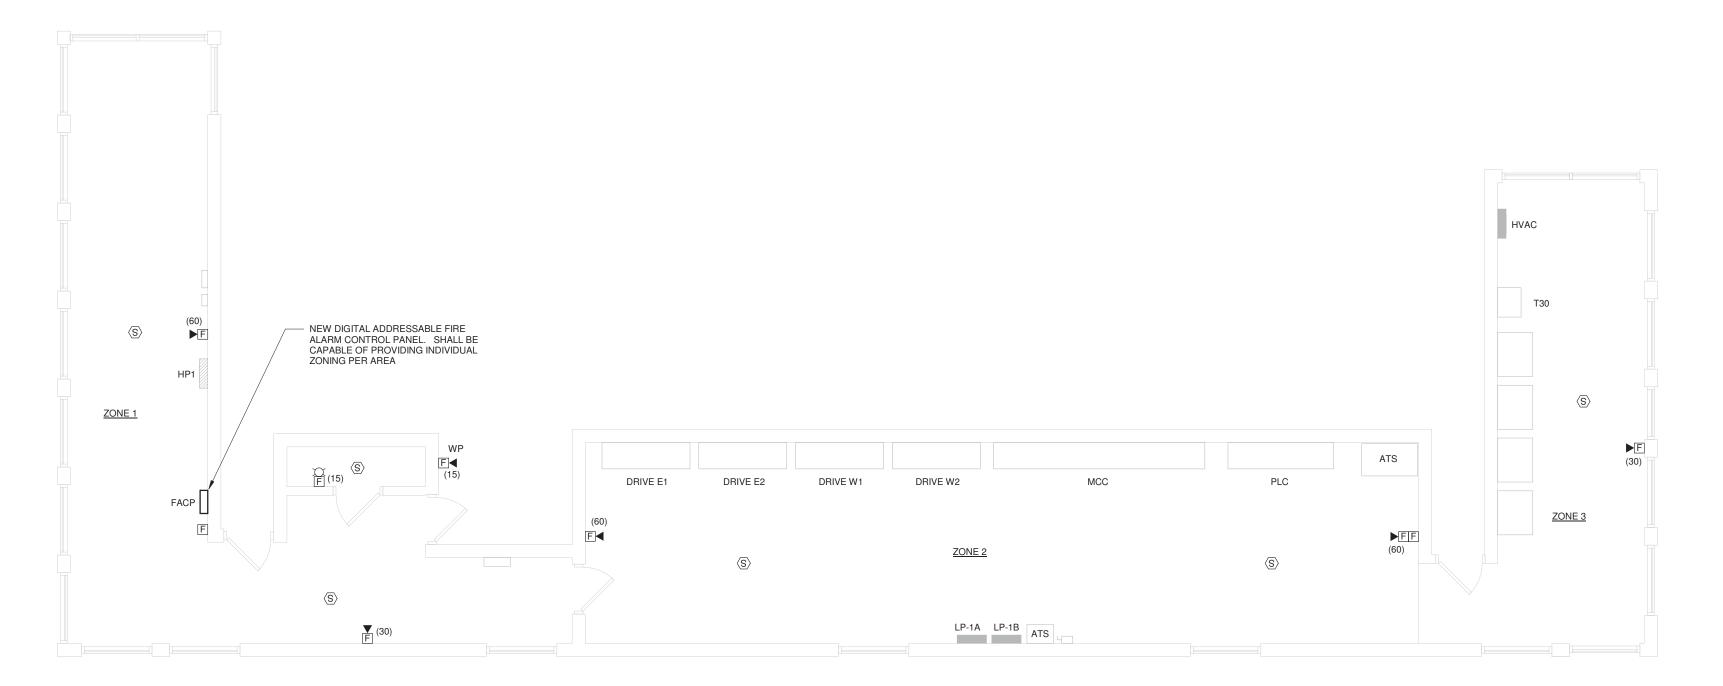

CONTROL HOUSE PLAN

CONTROL HOUSE AND TOWER PLANS - FIRE

ALARM

1/4" = 1'-0"



CENTERPOINT 2 MarketPlazaWay PHONE:(717) 795-8575 MECHANICSBURG, PA 17055 FAX: (717) 795-9110

As indicated

PROJECT 15BPR.15

CUMENTS ALL REPORTS, PLANS SPECIFICATIONS AND COMPUTER FILES RELATING TO THIS PROJECT ARE THE PROPERTY OF CRABTREE, ROHRBAUGH & ASSOCIATES. CRABTREE ROHRBAUGH & ASSOCIATES RETAINS ALL COMMON LAW, STATUTE AND OTHER RESERVED RIGHTS INCLUDING THE COPYRIGHT THERETO, REPRODUCTION OF THE MATERIAL HEREIN OR SUBSTANTIAL USE WITHOUT WRITTEN PERMISSION OF CRABTREE, ROHRBAUGH & ASSOCIATES VIOLATES THE COPYRIGHT LAWS OF THE UNITED STATES AND WILL BE SUBJECT TO LEGAL PROSECUTION.

© CRABTREE, ROHRBAUGH & ASSOCIATES, INC 2017 CONSTRUCTION %00 REVISIONS 01 MM-DD-YR NAME DESCRIPTION OF CHANGES

ARCHITE RENOVATIONS TO
CAPE FEAR RIVER MEMORIAL LIFT BRIDGE
NORTH CAROLINA DEPT. OF TRANSPORTATION **ASSO**(EST MAY) ROHRBAUGH & HILL ROAD | 250 WE

CRABTREE ROHR
401 EAST WINDING HILL ROAD
MECHANICSBURG PA 17055
717-458-0272 FAX 717-458-00

FLOOR PLANS - FIRE ALARM

FILENAME: 17066 Memorial Bridge NC Revit-17 ELECT.rvt

DECEMBER 20, 2017