


18 CHANNEL IP CONFLICT MONITOR
PROGRAMMING DETAIL

(remove jumpers and set switches as shown)

REMOVE DIODE JUMPERS 2-4, 2-5, 2-6, 2-11, 2-15, 4-5, 4-11, 4-12, 4-14, 5-11, 6-11, 6-15, 11-15, and 12-14.

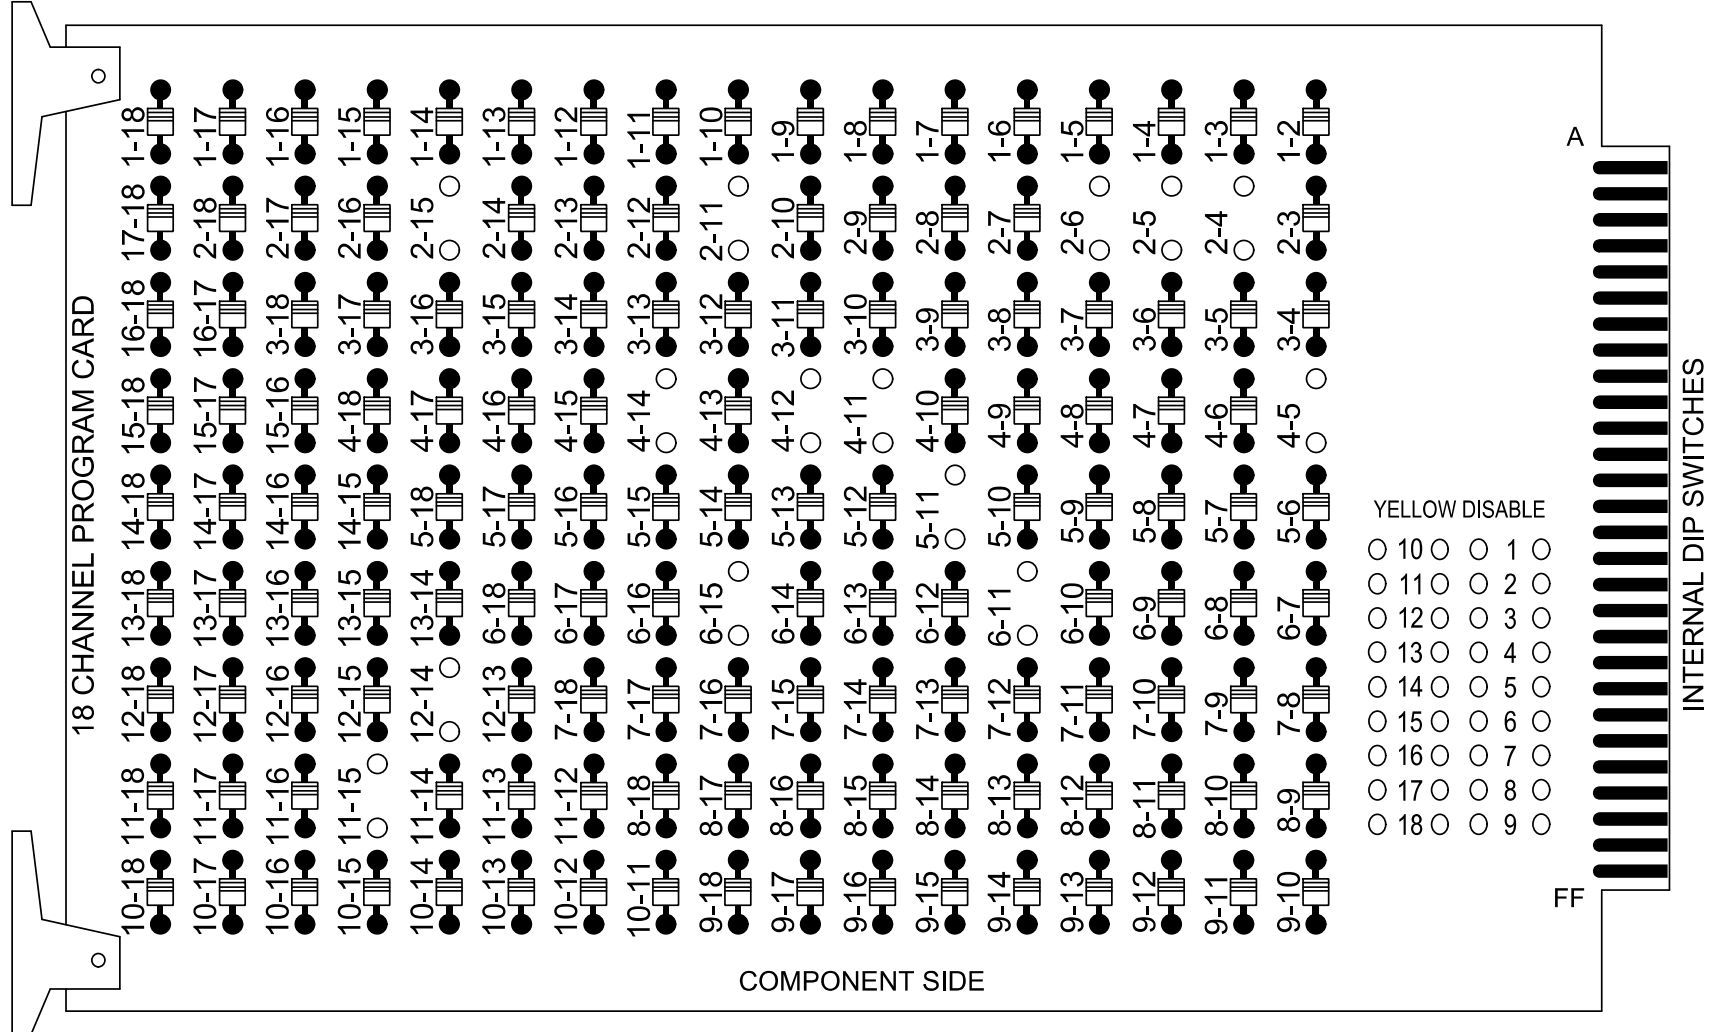

REMOVE JUMPERS AS SHOWN

NOTES:

- Card is provided with all diode jumpers in place. Removal of any jumper allows its channels to run concurrently.
- Ensure jumpers SEL2-SEL5 and SEL9 are present on the monitor board.
- Ensure that the Red Enable is active at all times during normal operation.
- Integrate monitor with Ethernet network in cabinet.

NOTES

- To prevent "flash-conflict" problems, insert red flash program blocks for all vehicle load switches in the output file. The installer shall verify that signal heads flash in accordance with the signal plan.
- Program controller to start up in phase 2 Green No Walk and 6 Green No Walk.
- If this signal will be managed by an ATMS software, enable controller and detector logging for all detectors used at this location.
- The cabinet and controller are part of the D10-43_Huntersville System.


EQUIPMENT INFORMATION

Controller.....2070LX
Cabinet.....332 w/ Aux
Software.....Q-Free MAXTIME
Cabinet Mount.....Base
Output File Positions.....18 With Aux. Output File
Load Switches Used.....S2, S5, S6, S7, S8, S9, AUX S4, AUX S5
Phases Used.....2, 4, 4PED, 5, 6, 6PED
Overlap "1".....NOT USED
Overlap "2".....NOT USED
Overlap "3".....*
Overlap "4".....*
Overlap "5".....NOT USED
Overlap "6".....NOT USED
Overlap "7".....*

*See overlap programming detail on sheet 2

INPUT FILE POSITION LAYOUT

(front view)

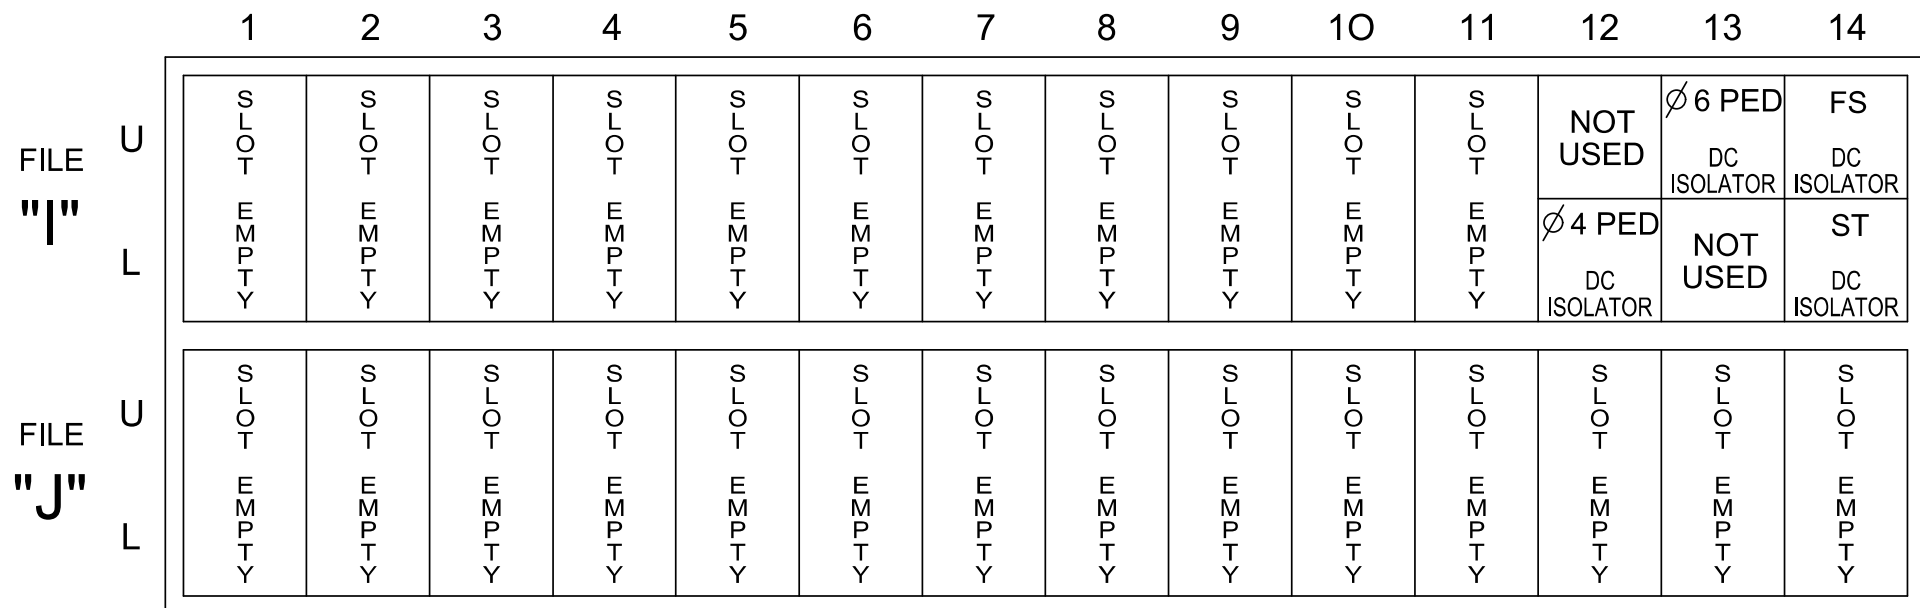

EX : 1A, 2A, ETC. = LOOP NO.'S

FS = FLASH SENSE
ST = STOP TIME

INPUT FILE CONNECTION & PROGRAMMING CHART

LOOP NO.	LOOP TERMINAL	INPUT FILE POS.	PIN NO.	INPUT POINT	DETECTOR NO.	CALL PHASE	DELAY TIME	EXTEND TIME	EXTEND	ADDED INITIAL	CALL	DELAY DURING GREEN
2A	-	-	-	*	38	2			X		X	
4A	-	-	-	*	44	4	3.0		X		X	
5A	-	-	-	*	35 ★	5	15.0		X		X	
				*	127 ★	2	3.0		X		X	X
5B	-	-	-	*	51	5	15.0		X		X	
6A	-	-	-	*	54	6			X		X	
PED PUSH BUTTONS												
P41,P42	TB8-5,6	I12L	69	35	4	PED 4						
P61,P62	TB8-7,9	I13U	68	34	6	PED 6						


* For Input Point numbers, see SDLC NON-INTRUSIVE DETECTION CHART this sheet.
★ For the detector to work as shown on the signal design plan, see the Vehicle Detector Setup Programming Detail for Alternate Phasing on sheet 3.

* SDLC NON-INTRUSIVE
DETECTION CHART

	DETECTOR RACK #3		DETECTOR RACK #4	
Input Point	DET # (Index)	Detector Zone	Det # (Index)	Detector Zone
1	33	NU	49	NU
2	34	NU	50	NU
3	35	5A	51	5B
4	36	NU	52	NU
5	37	NU	53	NU
6	38	2A	54	6A
7	39	NU	55	NU
8	40	NU	56	NU
9	41	NU	57	NU
10	42	NU	58	NU
11	43	NU	59	NU
12	44	4A	60	NU
13	45	NU	61	NU
14	46	NU	62	NU
15	47	NU	63	NU
16	48	NU	64	NU

NU = Not Used

 INPUT FILE POSITION LEGEND: J2L



SIGNAL HEAD HOOK-UP CHART


LOAD SWITCH NO.	S1	S2	S3	S4	S5	S6	S7	S8	S9	S10	S11	S12	AUX S1	AUX S2	AUX S3	AUX S4	AUX S5	AUX S6
CMU CHANNEL NO.	1	2	13	3	4	14	5	6	15	7	8	16	9	10	17	11	12	18
PHASE	1	2	2 PED	3	OL7	4 PED	5	6	6 PED	7	8	8 PED	OL1	OL2	SPARE	OL3	OL4	SPARE
SIGNAL HEAD NO.	NU	21,22	NU	NU	42,43	P41, P42	51★	61	62	P61, P62	NU	NU	NU	NU	NU	51★	41★	NU
RED		128			101			134	134									
YELLOW		129					★	135	135									
GREEN		130							136									
RED ARROW																A114	A101	
YELLOW ARROW					102											A115	A102	
FLASHING YELLOW ARROW																A116	A103	
GREEN ARROW					103		133	136										
Hand icon						104				119								
Walking person icon						106				121								

NU = Not Used

★ Denotes install load resistor. See load resistor installation detail this sheet.
★ See pictorial of head wiring in detail this sheet.

FYA SIGNAL WIRING DETAIL

(wire signal heads as shown)

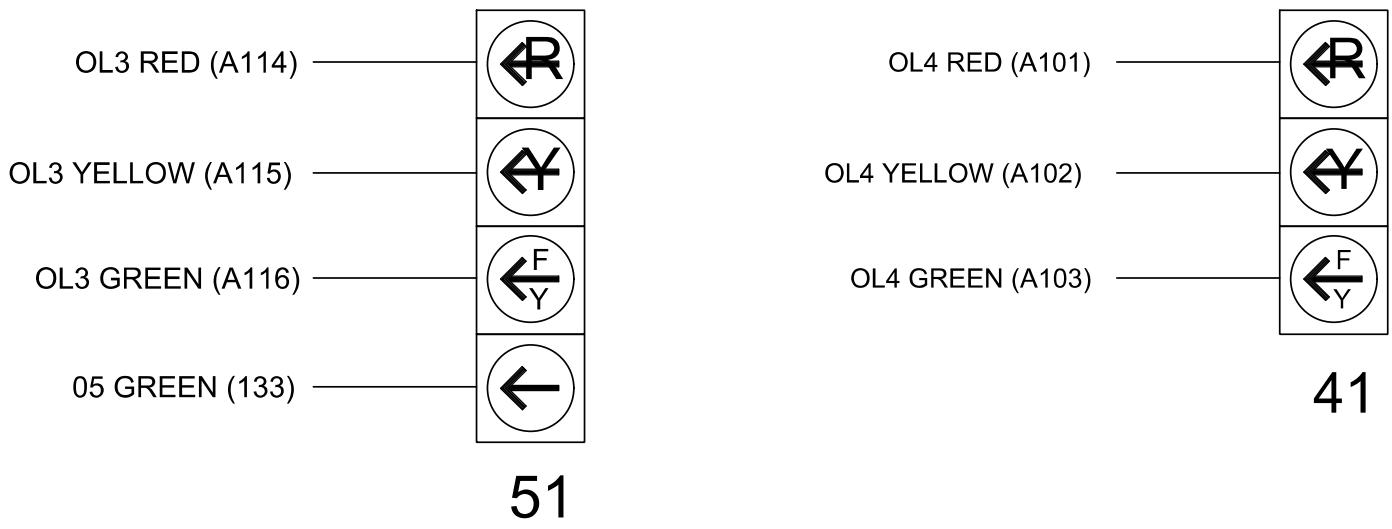

COUNTDOWN PEDESTRIAN SIGNAL OPERATION

Countdown Ped Signals are required to display timing only during Ped Clearance Interval. Consult Ped Signal Module user's manual for instructions on selecting this feature.


SPECIAL DETECTOR NOTE

Install a multi-zone microwave detection system for vehicle detection. Perform installation according to manufacturer's directions and NCDOT engineer -approved mounting locations to accomplish the detection schemes shown on the Signal Design Plans.

LOAD RESISTOR INSTALLATION DETAIL

(install resistor as shown)


ACCEPTABLE VALUES	
Value (ohms)	Wattage
1.5K - 1.9K	25W (min)
2.0K - 3.0K	10W (min)

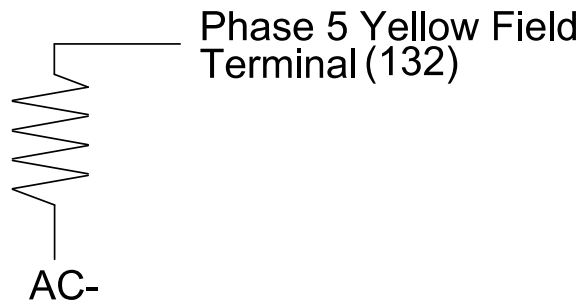

THIS ELECTRICAL DETAIL IS FOR
THE SIGNAL DESIGN: 10-2644
DESIGNED: January 2026
SEALED: 6/22/2026
REVISED: N/A

Electrical Details - Sheet 1 of 3

ELECTRICAL AND PROGRAMMING
DETAILS FOR:

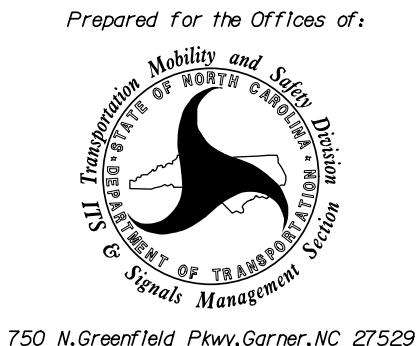

US 21 (Statesville Road)
at
Caldwell Creek Drive


Division 10 Mecklenburg County Huntersville

PLAN DATE: January 2026 REVIEWED BY: SL Phillips


PREPARED BY: SP Pennington REVIEWED BY:

REVISIONS INIT. DATE

DOCUMENT NOT CONSIDERED
FINAL UNLESS ALL
SIGNATURES COMPLETED

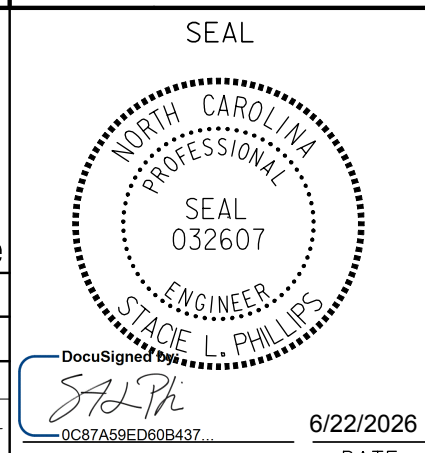


PLANS PREPARED IN THE OFFICE OF:
KimleyHorn
NC License #F-0102
421 Fayetteville Street, Suite 600
Raleigh, NC 27601
(919) 677-2000

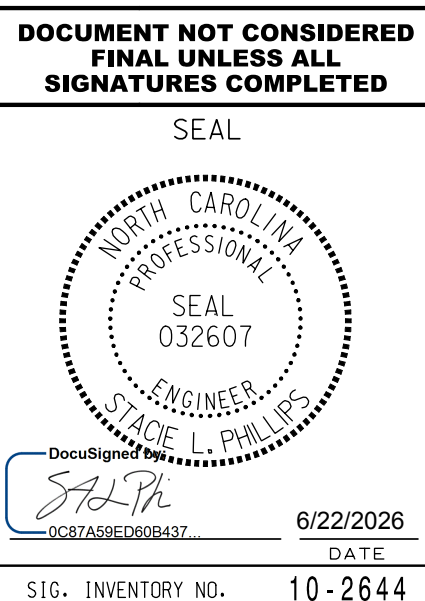

STATE OF NORTH CAROLINA

DIVISION OF HIGHWAYS

STANDARD DRAWINGS FOR ALL METAL POLES (LRFD)

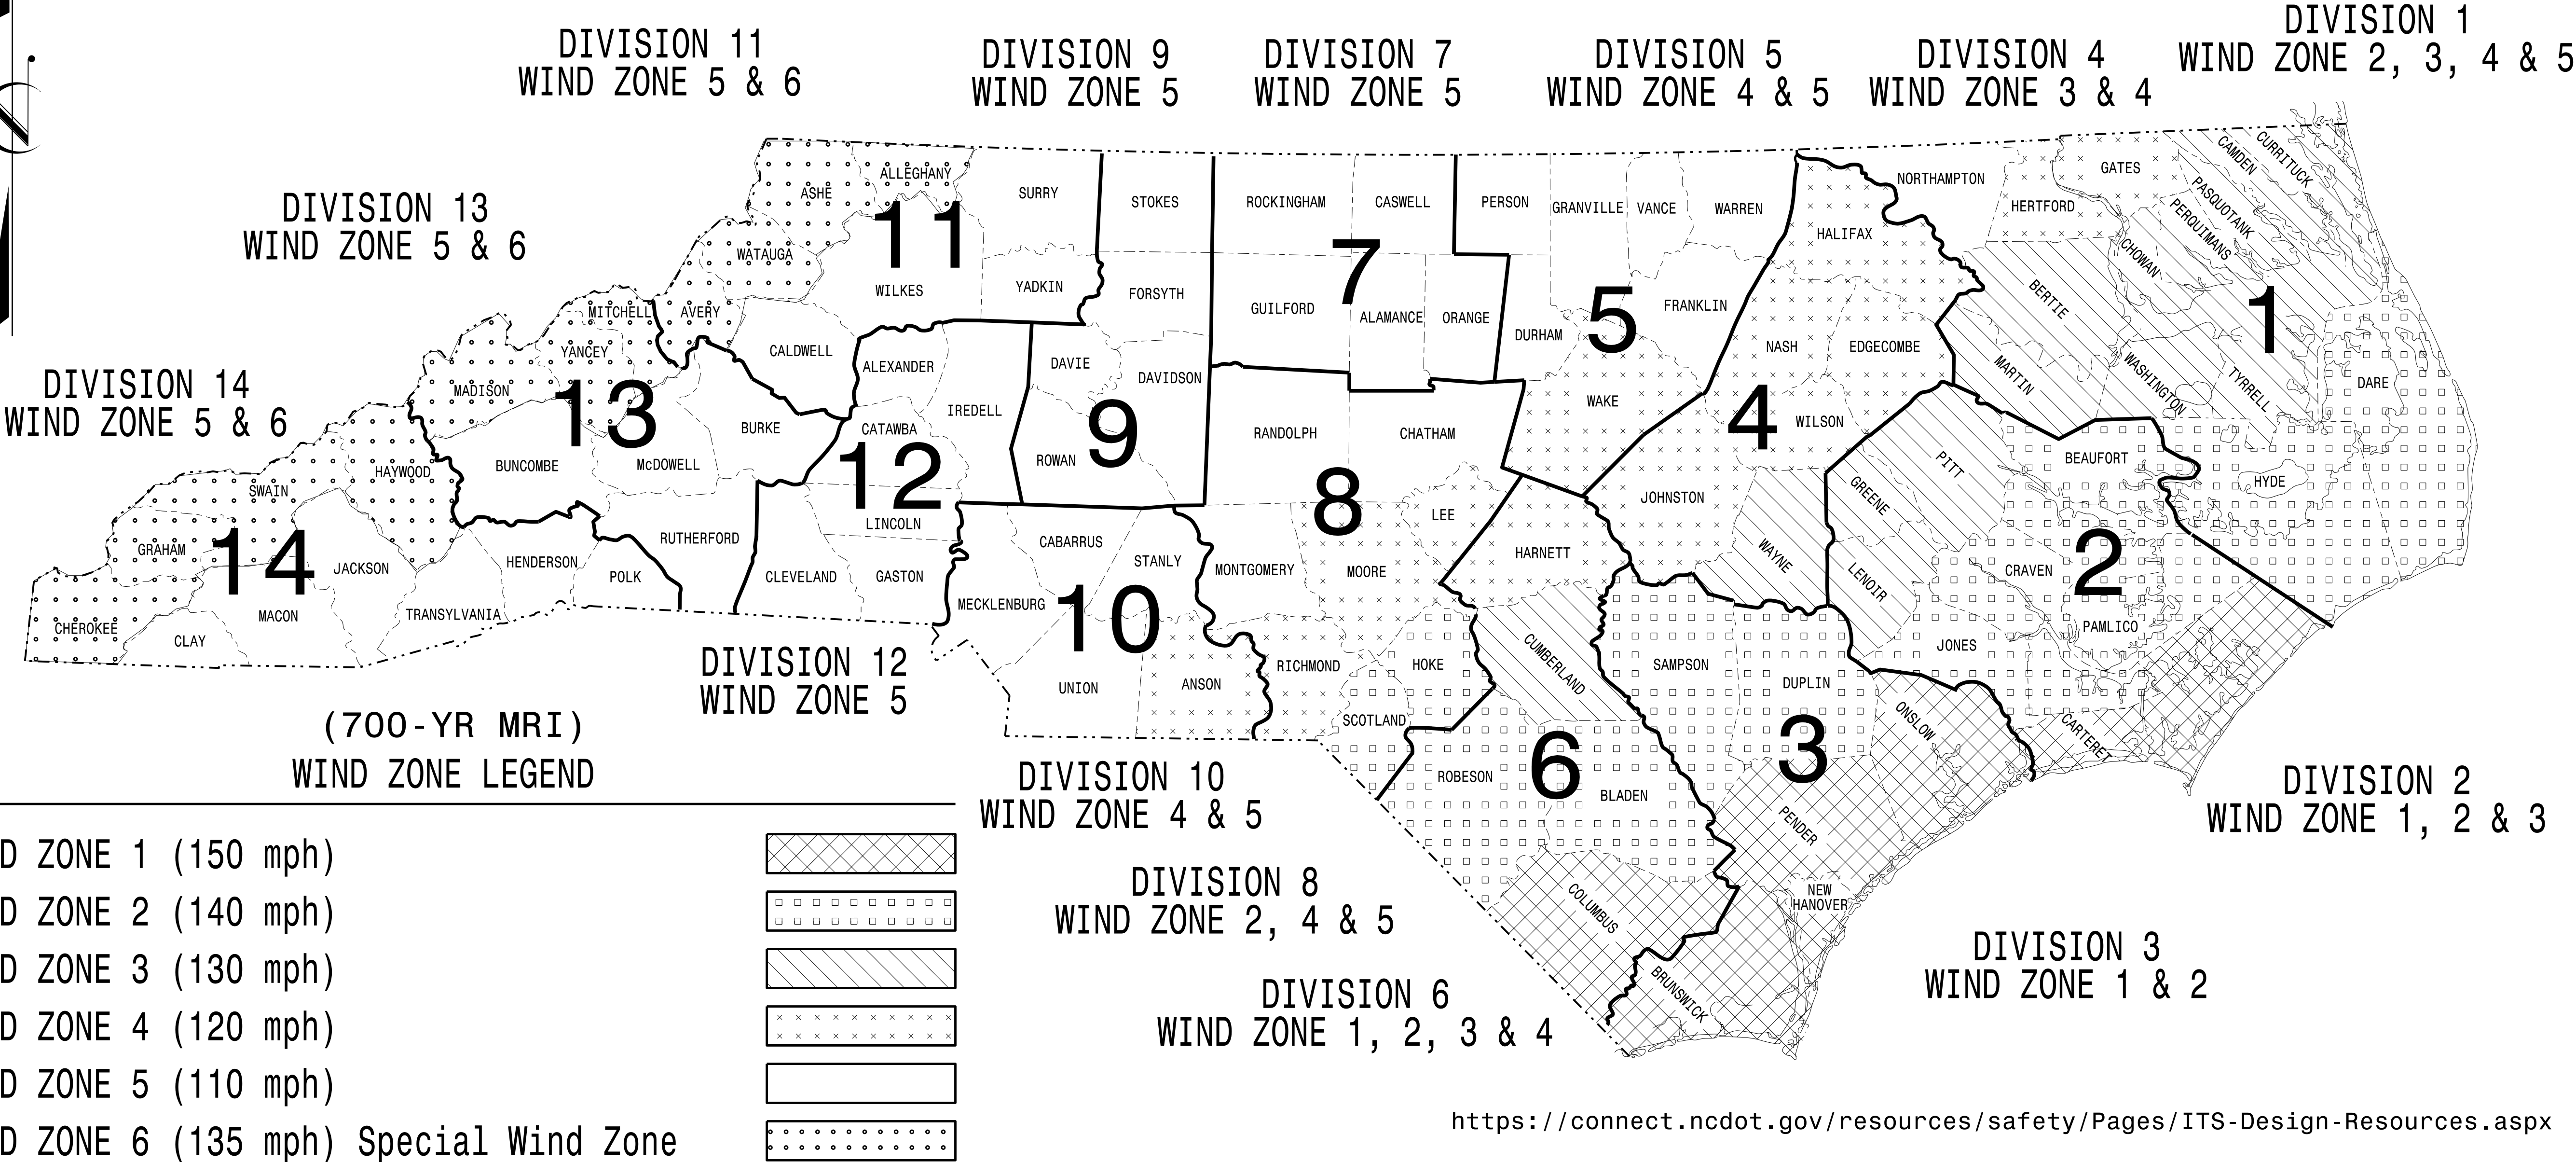

NCDOT METAL POLE STANDARDS

Prepared In the Offices of:



750 N. Greenfield Pkwy.
Garner, NC 27529

Designed in conformance
with the latest
2020 Interim to the
1st Edition 2015

AASHTO
LRFD

Standard Specifications for
Highway Signs, Luminaires,
and Traffic Signals


DRAWING
NUMBER

INDEX OF PLANS	
DESCRIPTION	
Sig. M 1A	Statewide Wind Zone Map (700-yr MRI)
Sig. M 1B	Statewide Wind Zone Map (10-yr MRI)
Sig. M 2	Typical Fabrication Details-All Metal Poles
Sig. M 3	Typical Fabrication Details-Strain Poles
Sig. M 4	Typical Fabrication Details-Mast Arm Poles
Sig. M 5	Typical Fabrication Details-Mast Arm Connection
Sig. M 6	Typical Fabrication Details-Strain Pole Attachments
Sig. M 7	Construction Details-Foundations
Sig. M 8	Standard Strain Pole Foundation-All Soil Conditions
Sig. M 9	Typical Fabrication Details-CCTV Camera Poles

MOBILITY AND SAFETY DIVISION -
TRANSPORTATION SYSTEMS MANAGEMENT
AND OPERATIONS UNIT


D.Y. ISHAK - STATE SIGNALS ENGINEER
K. DURIGON, P.E. - ITS AND SIGNALS STRUCTURAL ENGINEER
B. WALKER, P.E. - ITS AND SIGNALS STRUCTURAL ENGINEER

SEAL

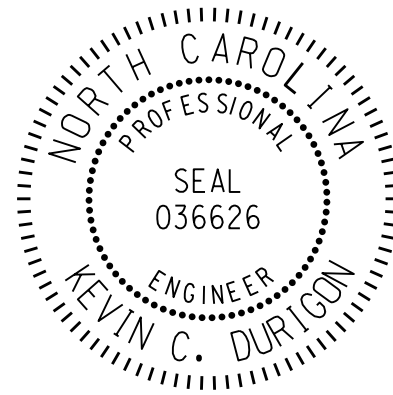

DocuSigned by:
Kevin Durigon
SIGNATURE
4B23DC79B3764DA

09/21/2023
DATE

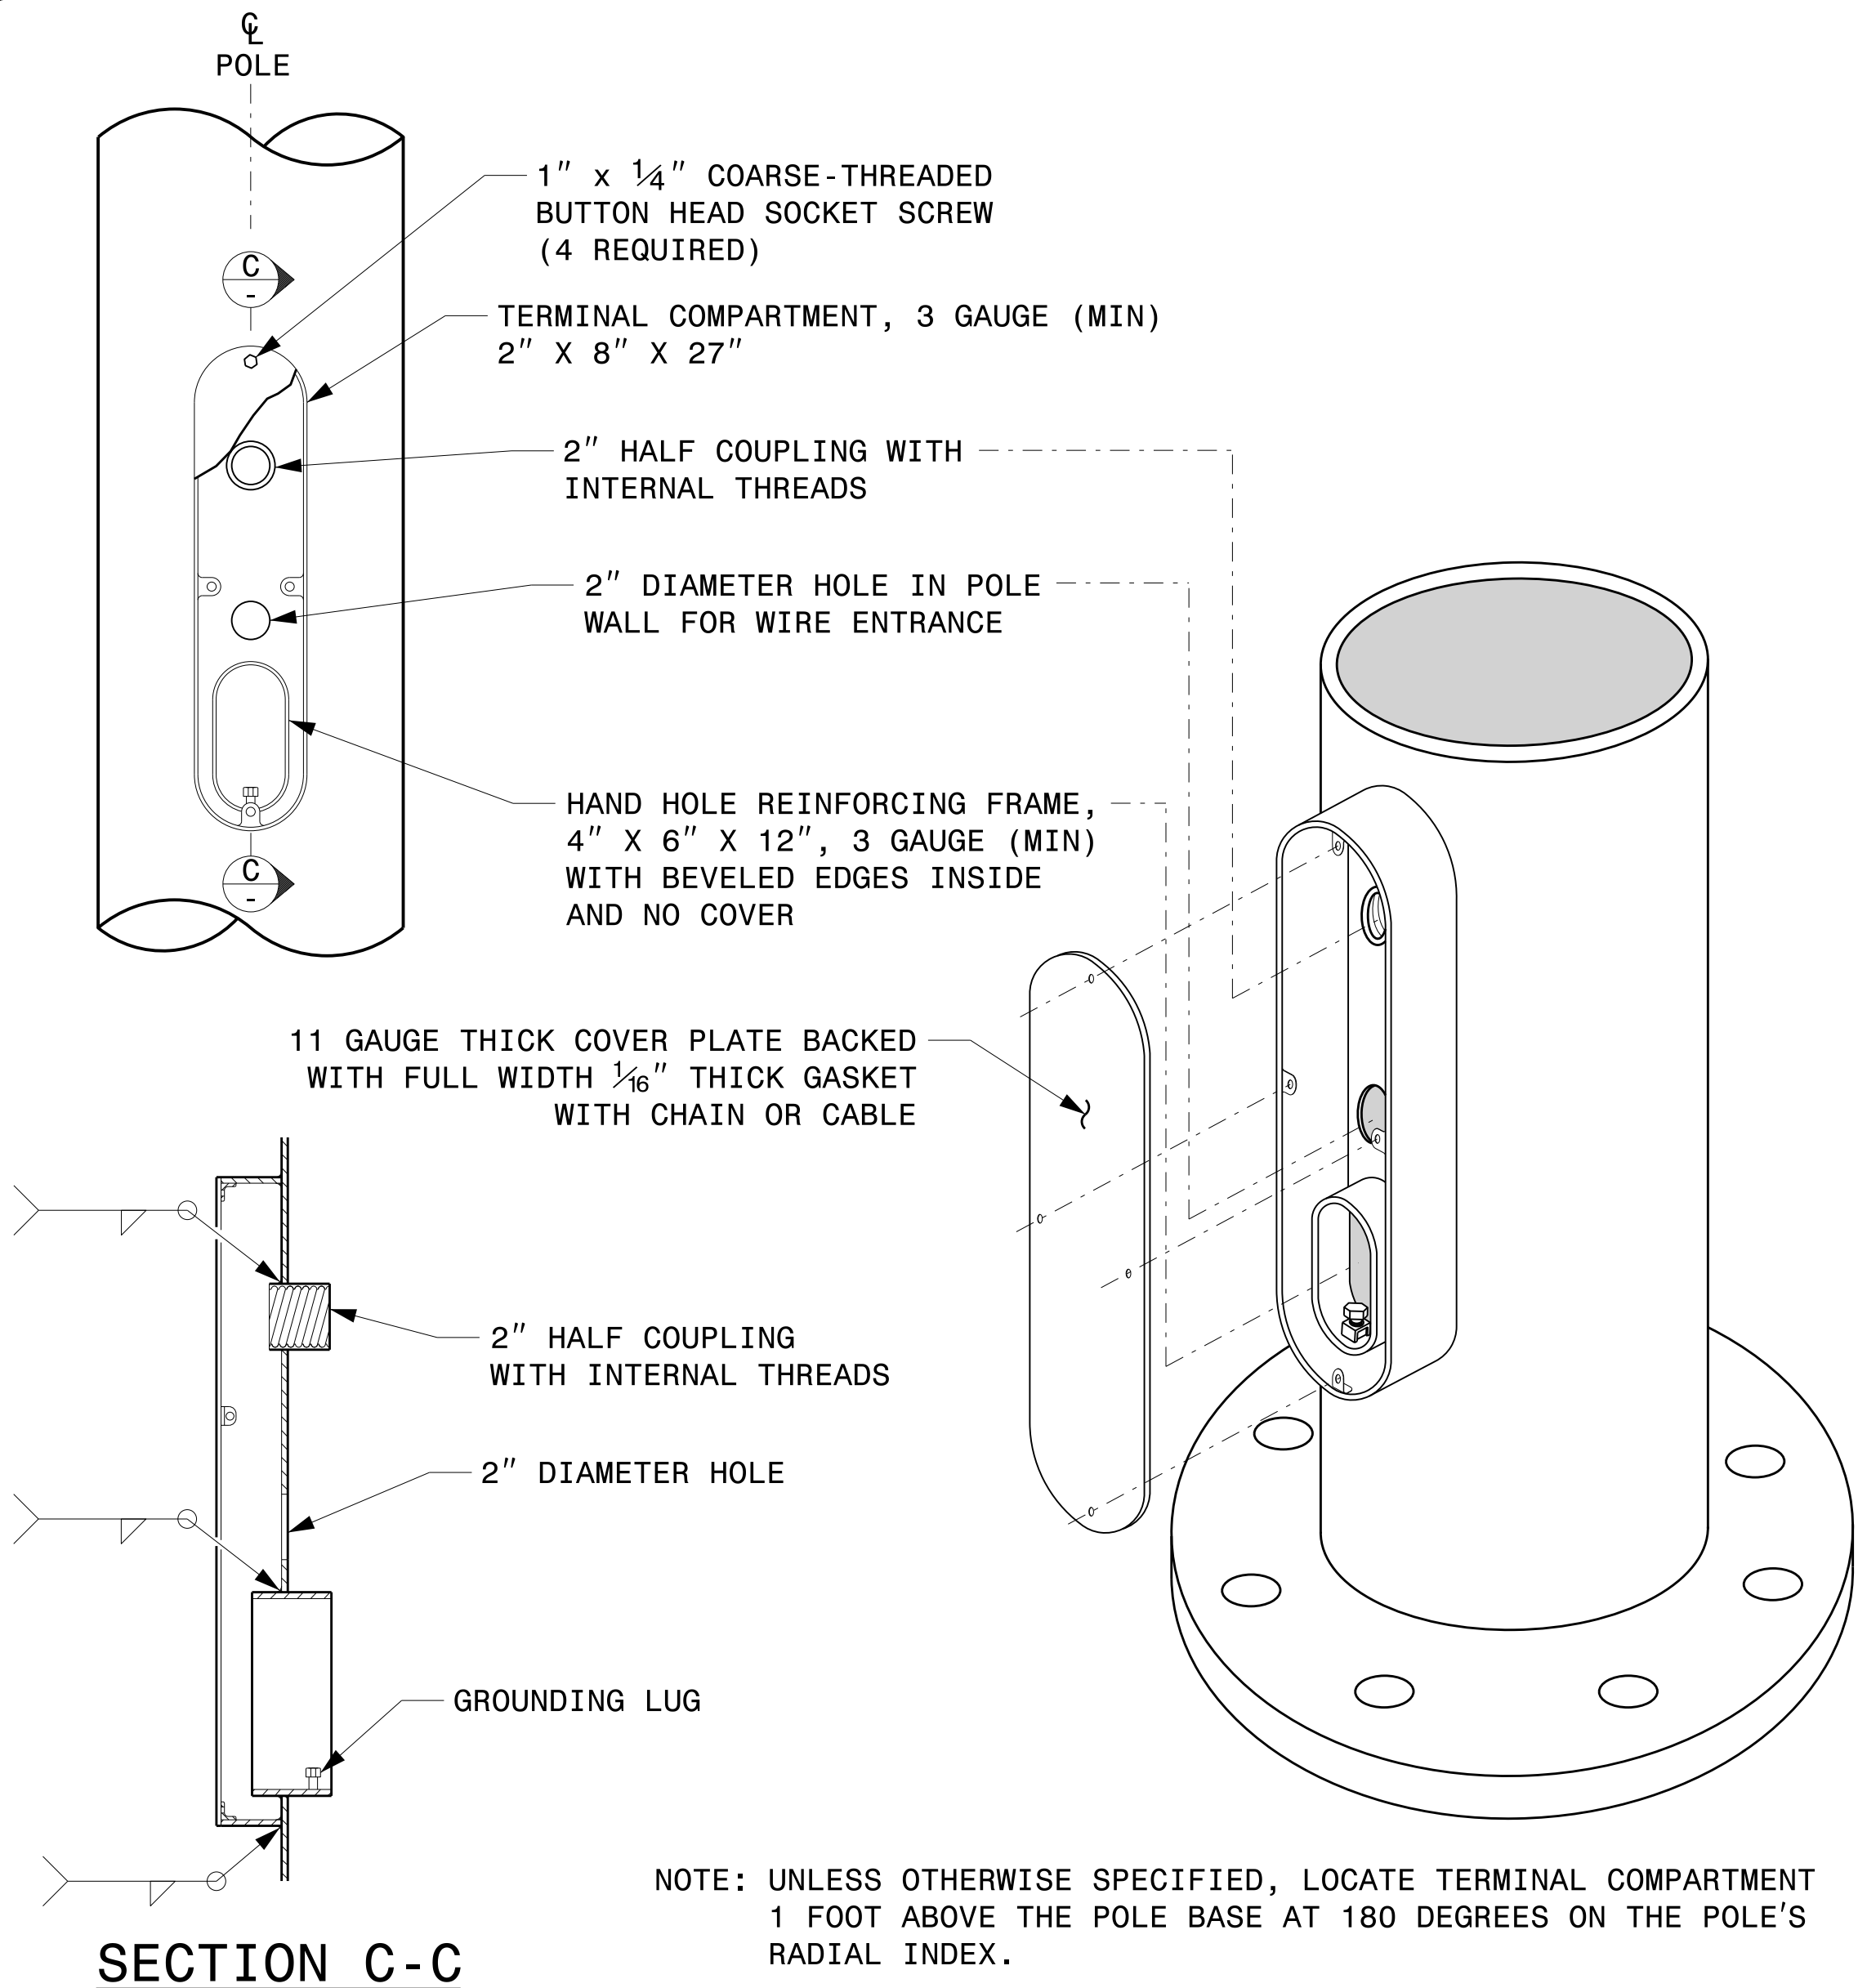

TERMINAL COMPARTMENT DETAIL

MFG _____	MFG. DATE: MM/YY _____
SHAFT D/T/L/Y _____	_____
ARM-A D/T/L/Y _____	_____
ARM-B D/T/L/Y _____	_____
A.B. DIA./B.C./L/Y _____	_____
NCDOT SIG. INV. NO. _____	_____
NCDOT POLE NO. _____	_____

SHAFT I.D. TAG
(PROVIDE ON SHAFT OF STRAIN POLES
AND MAST ARM POLE SHAFT)


MFG _____	MFG. DATE: MM/YY _____
SECTION D/T/L/Y _____	_____
NCDOT SIG. INV. NO. _____	_____
NCDOT POLE NO. _____	_____

ARM I.D. TAG
(PROVIDE ON EACH SECTION OF
A MULTI-SECTION MAST ARM)

NOTES:


- D = DIAMETER, T = THICKNESS, L = LENGTH, Y = YIELD STRENGTH
- A.B. = ANCHOR BOLT
- B.C. = BOLT CIRCLE OF ANCHOR BOLTS
- IF STANDARD DESIGN, INCLUDE CASE NUMBER IN ADDITION TO POLE NUMBER ON "NCDOT POLE NO." LINE.
- SIGNAL INV. NUMBER AND POLE I.D. NUMBER.
SEE DRAWING M3 AND M4 FOR MOUNTING POSITIONS OF I.D. TAGS.

IDENTIFICATION TAG DETAILS

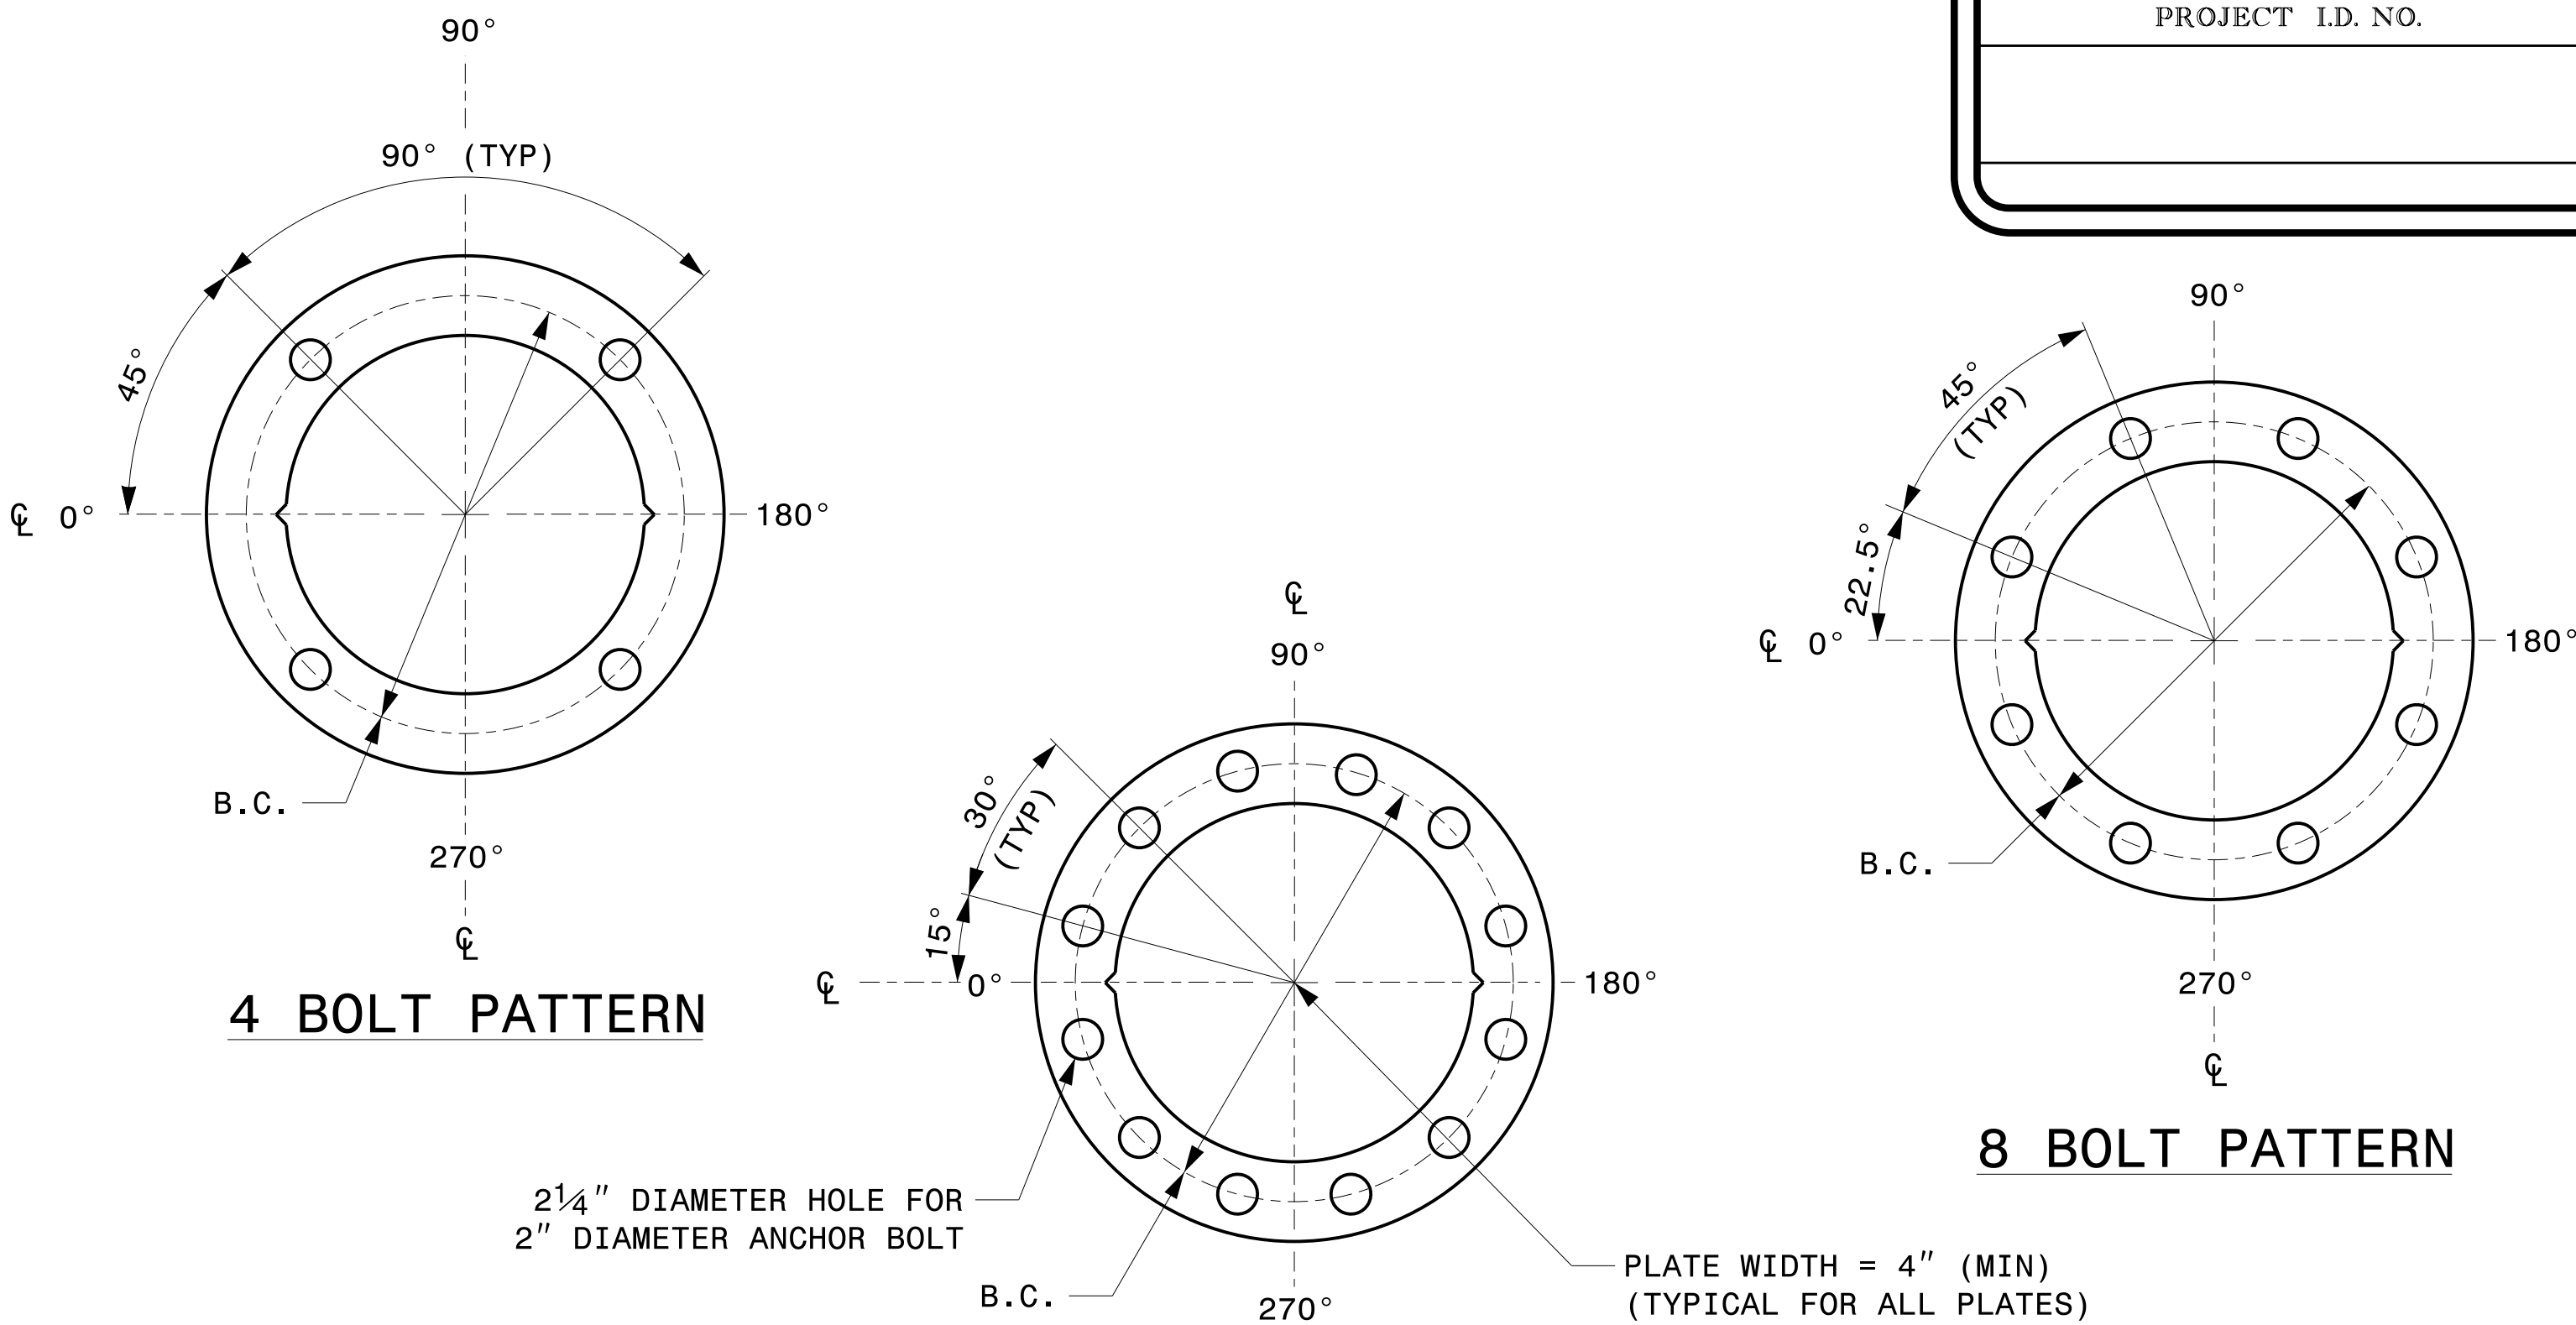


CONSTRUCT TEMPLATES AND PLATES FROM 1/4" (MIN) THICK STEEL. GALVANIZING IS NOT REQUIRED.

BASE PLATE TEMPLATE AND ANCHOR BOLT LOCK PLATE DETAILS

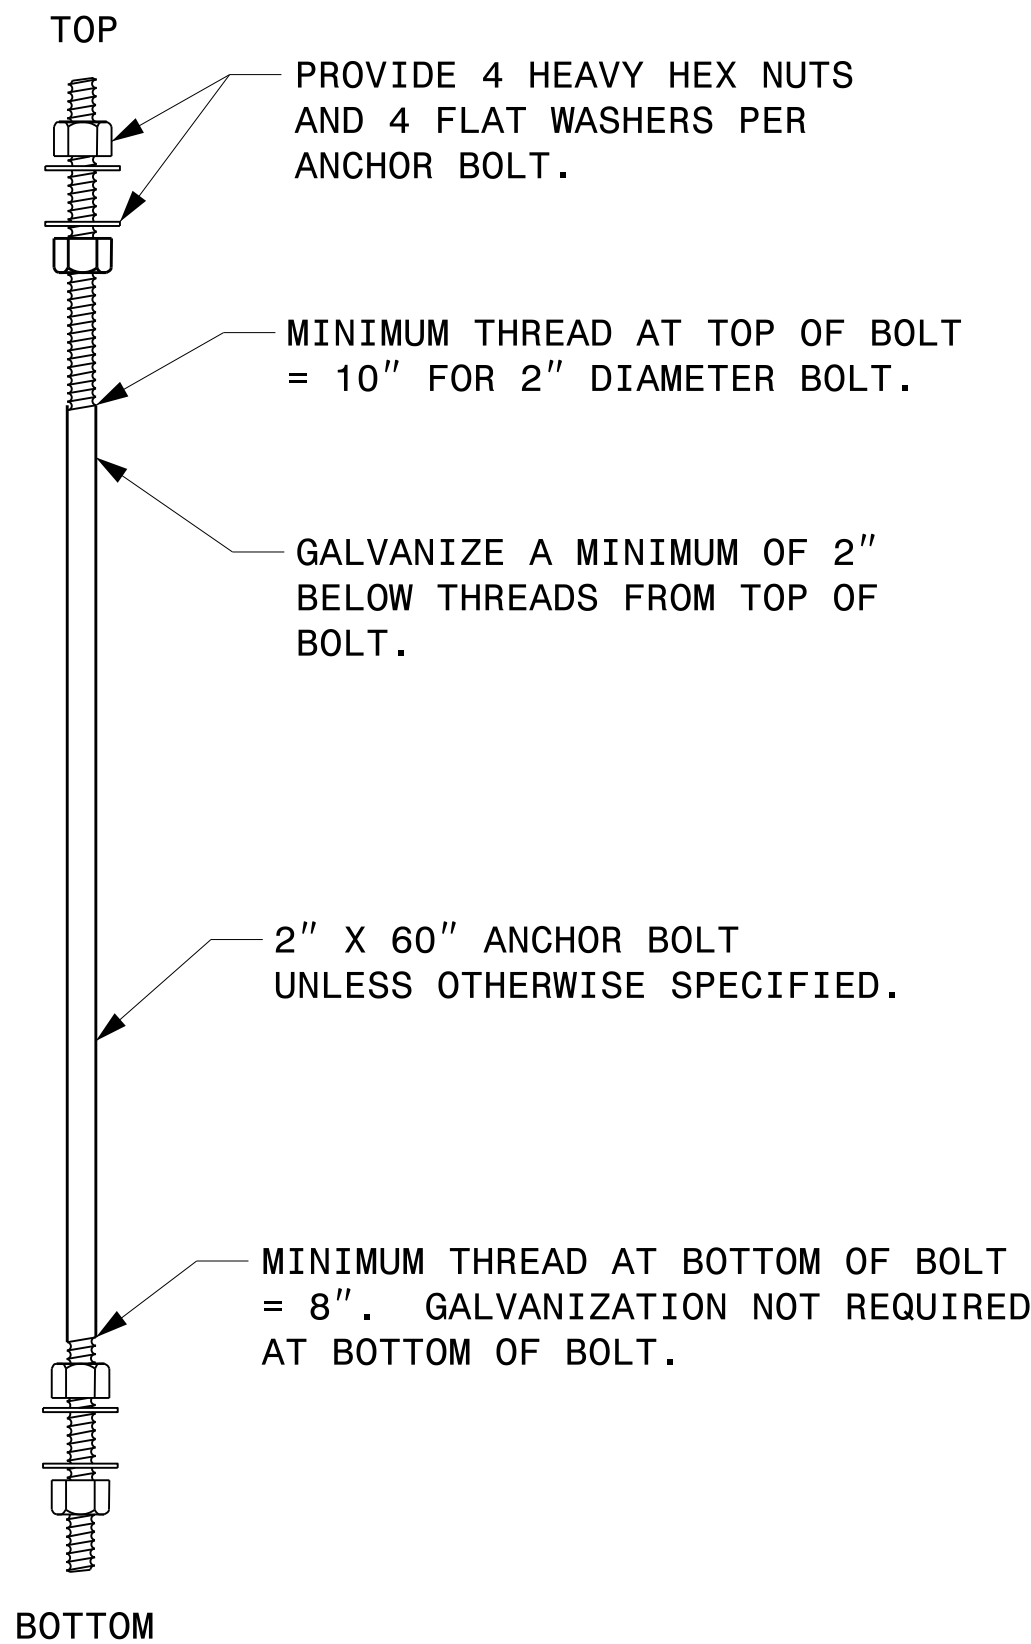

ANCHOR BOLT DETAIL

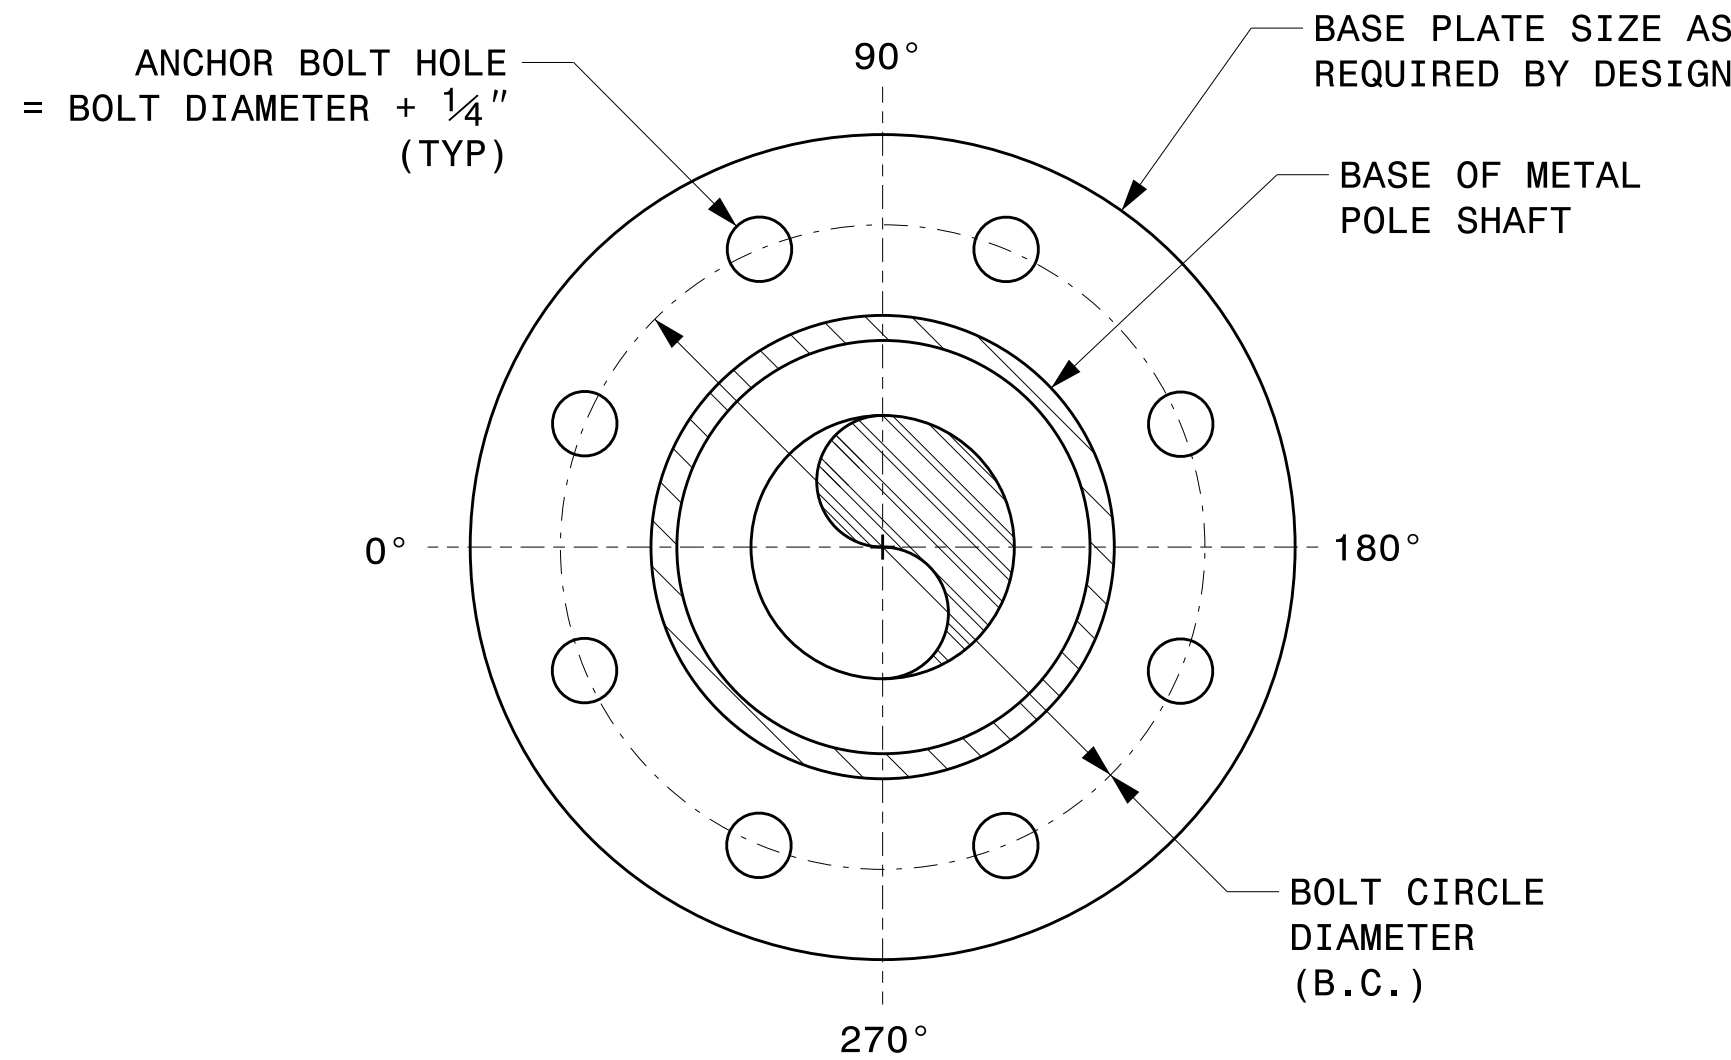

NOTE: BASE PLATE MAY BE CIRCULAR, OCTAGONAL, SQUARE OR RECTANGULAR IN SHAPE.

TYPICAL BASE PLATE DETAIL

Prepared In the Offices of:

750 N. Greenfield Pkwy, Garner, NC 27529

SCALE: NA

NONE

Typical Fabrication Details
For
All Metal Poles

PLAN DATE: SEPTEMBER 2023 DESIGNED BY: C.F. ANDREWS

PREPARED BY: K.C. DURIGON REVIEWED BY: D.C. SARKAR

REVISIONS: INIT. DATE


SEAL

DocuSigned by:
Kevin Durigon
4B23DC79B3784DA


09/21/2023
DATE

NOTE:

1. OPENING IN POLE BASE PLATE SHALL BE EQUAL TO POLE BASE INSIDE DIAMETER MINUS $3\frac{1}{2}$ " BUT SHALL NOT BE LESS THAN $8\frac{1}{2}$ ".

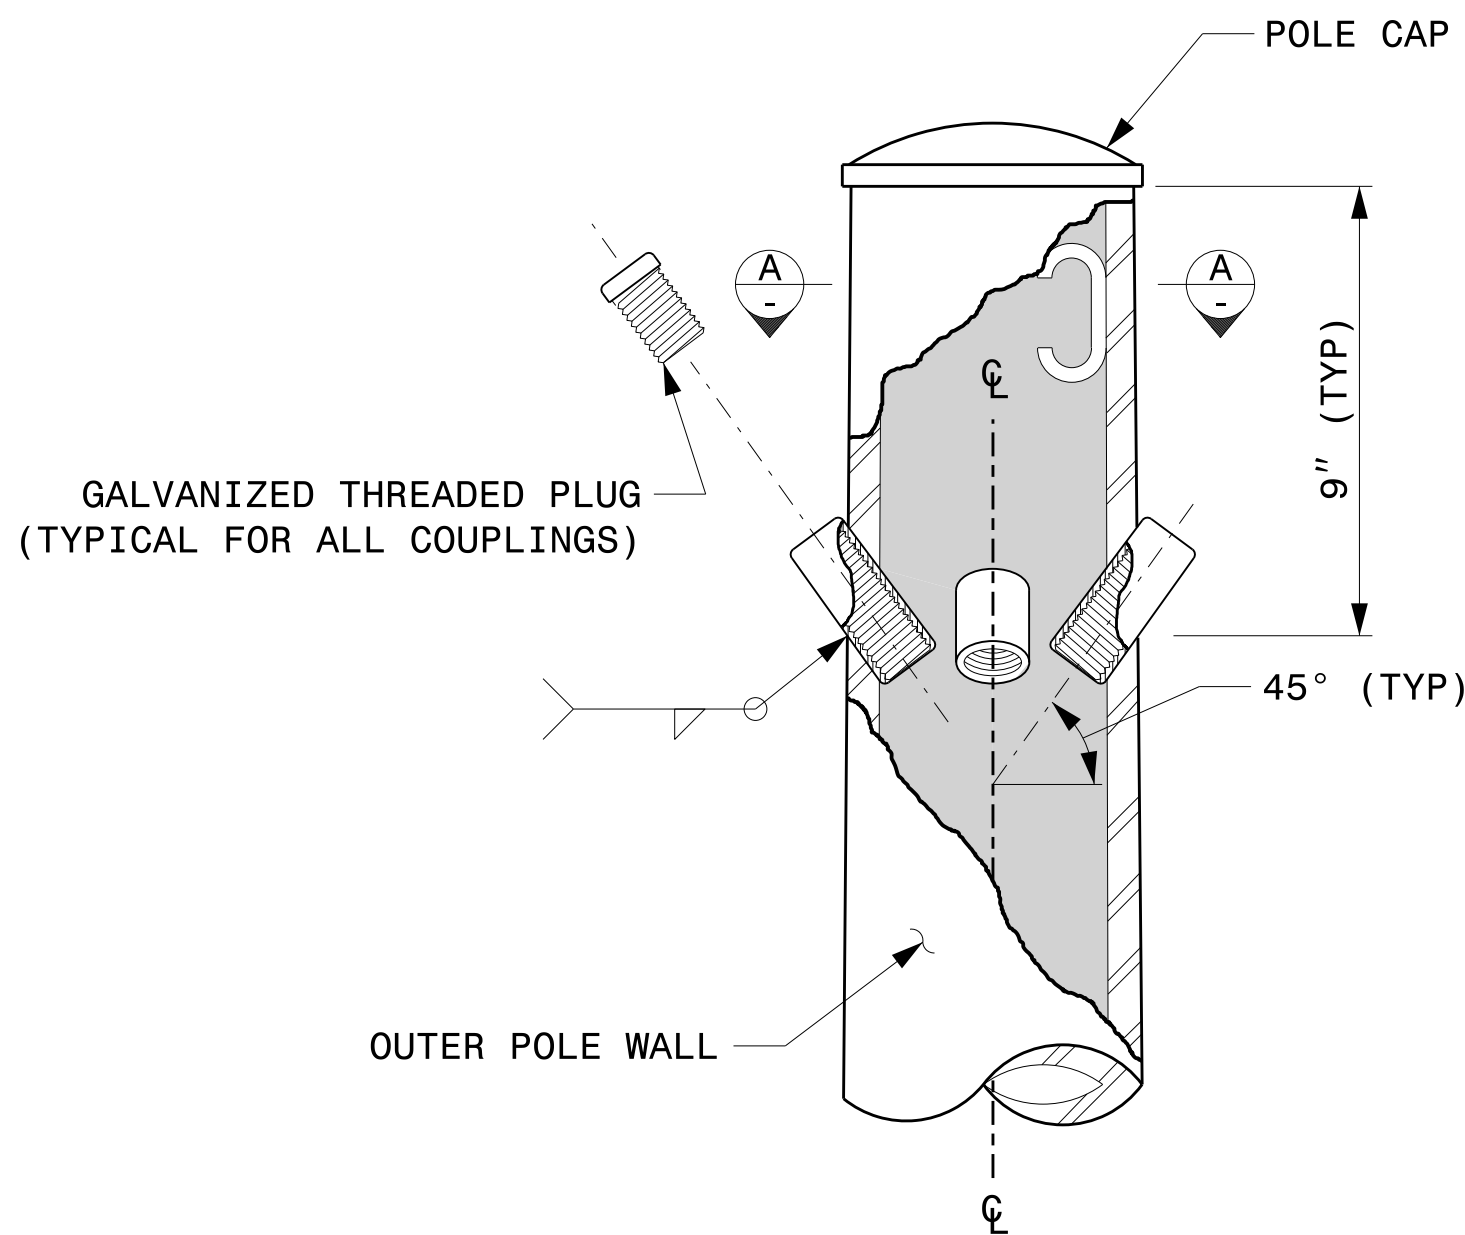


CABLE ENTRANCES AT TOP OF POLE

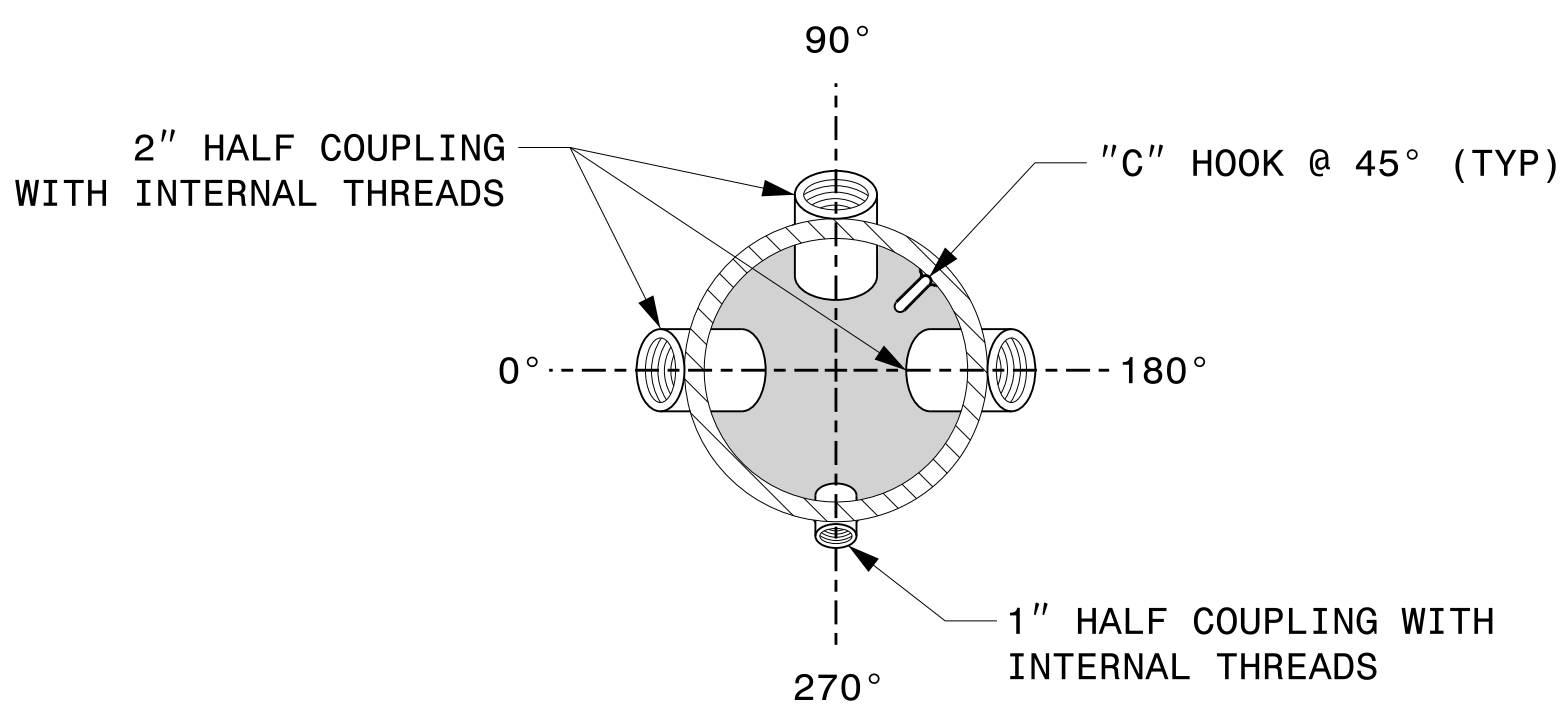


SECTION A-A

RADIAL ORIENTATION OF FACTORY INSTALLED ACCESSORIES AT TOP OF POLE

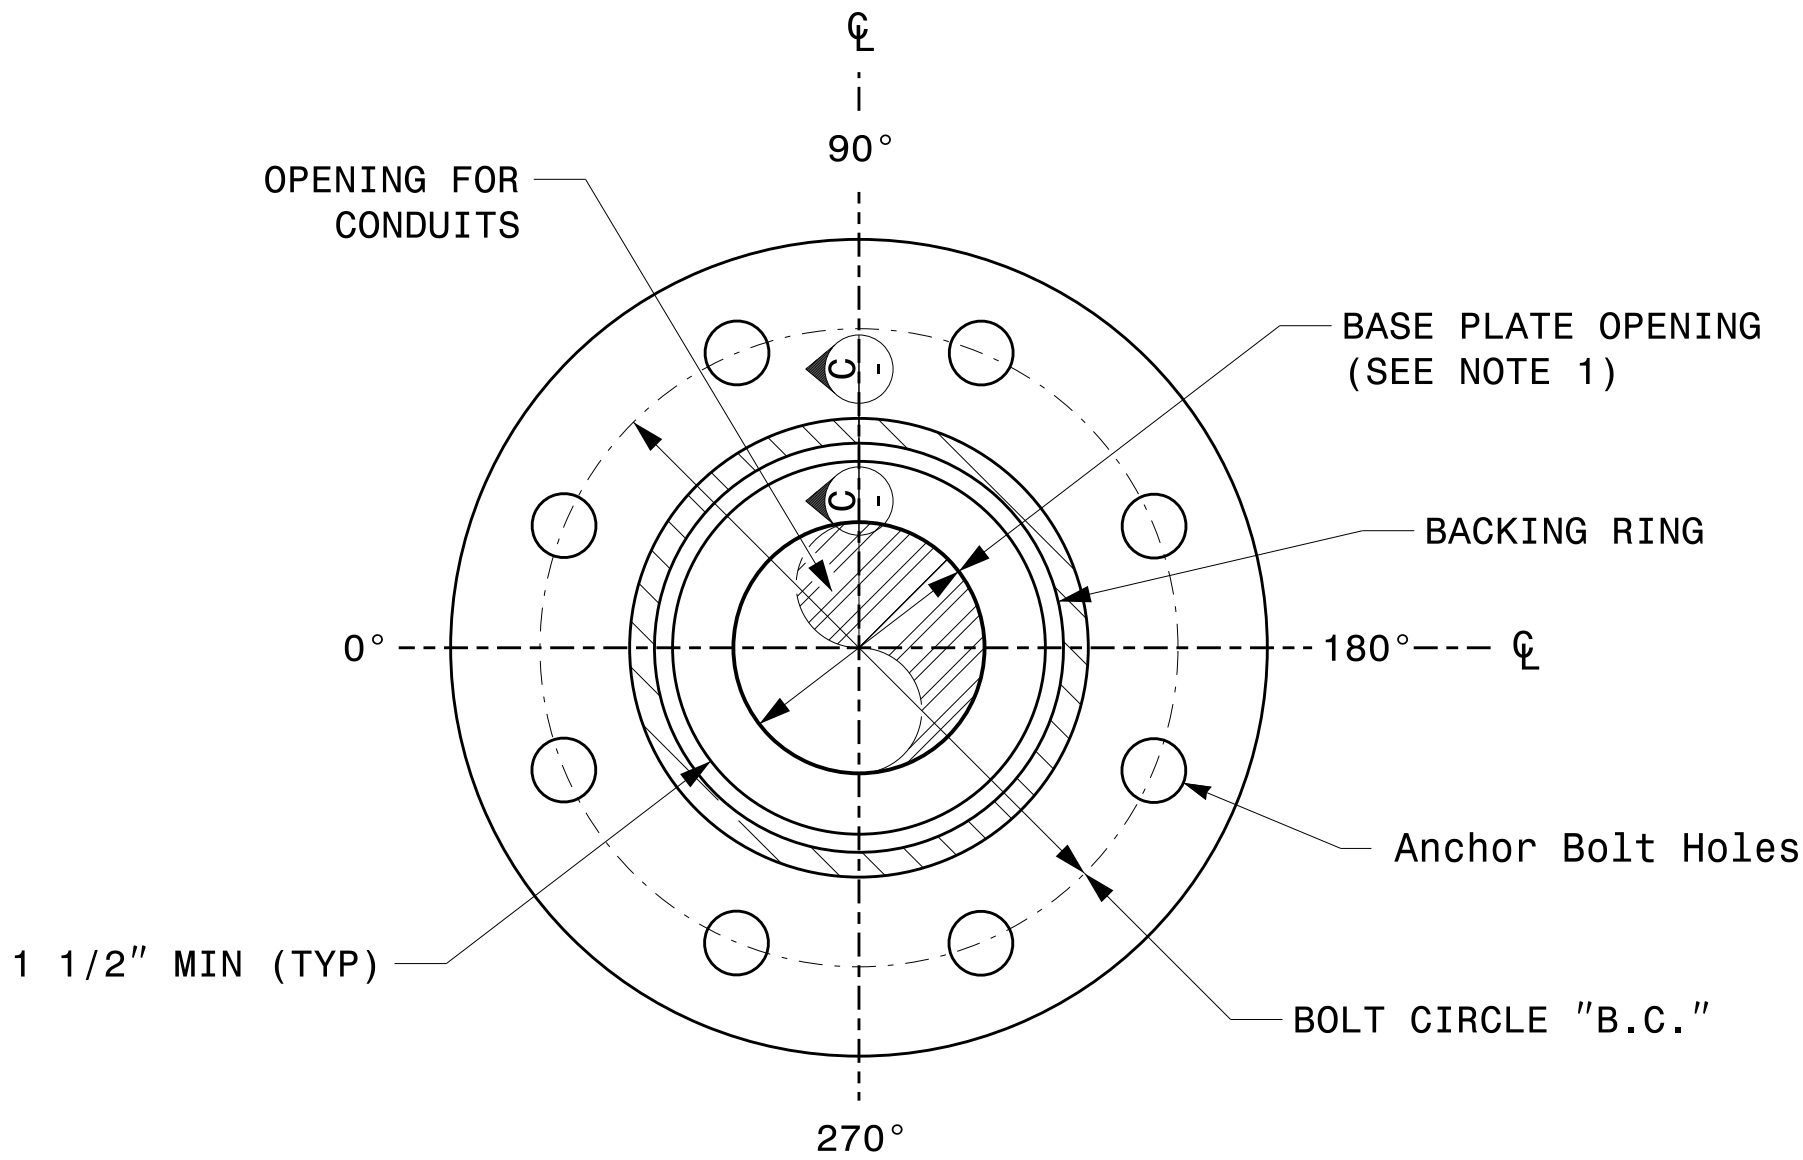

SECTION B-B


POLE BASE PLATE DETAILS
(8 AND 12 BOLT PATTERN)

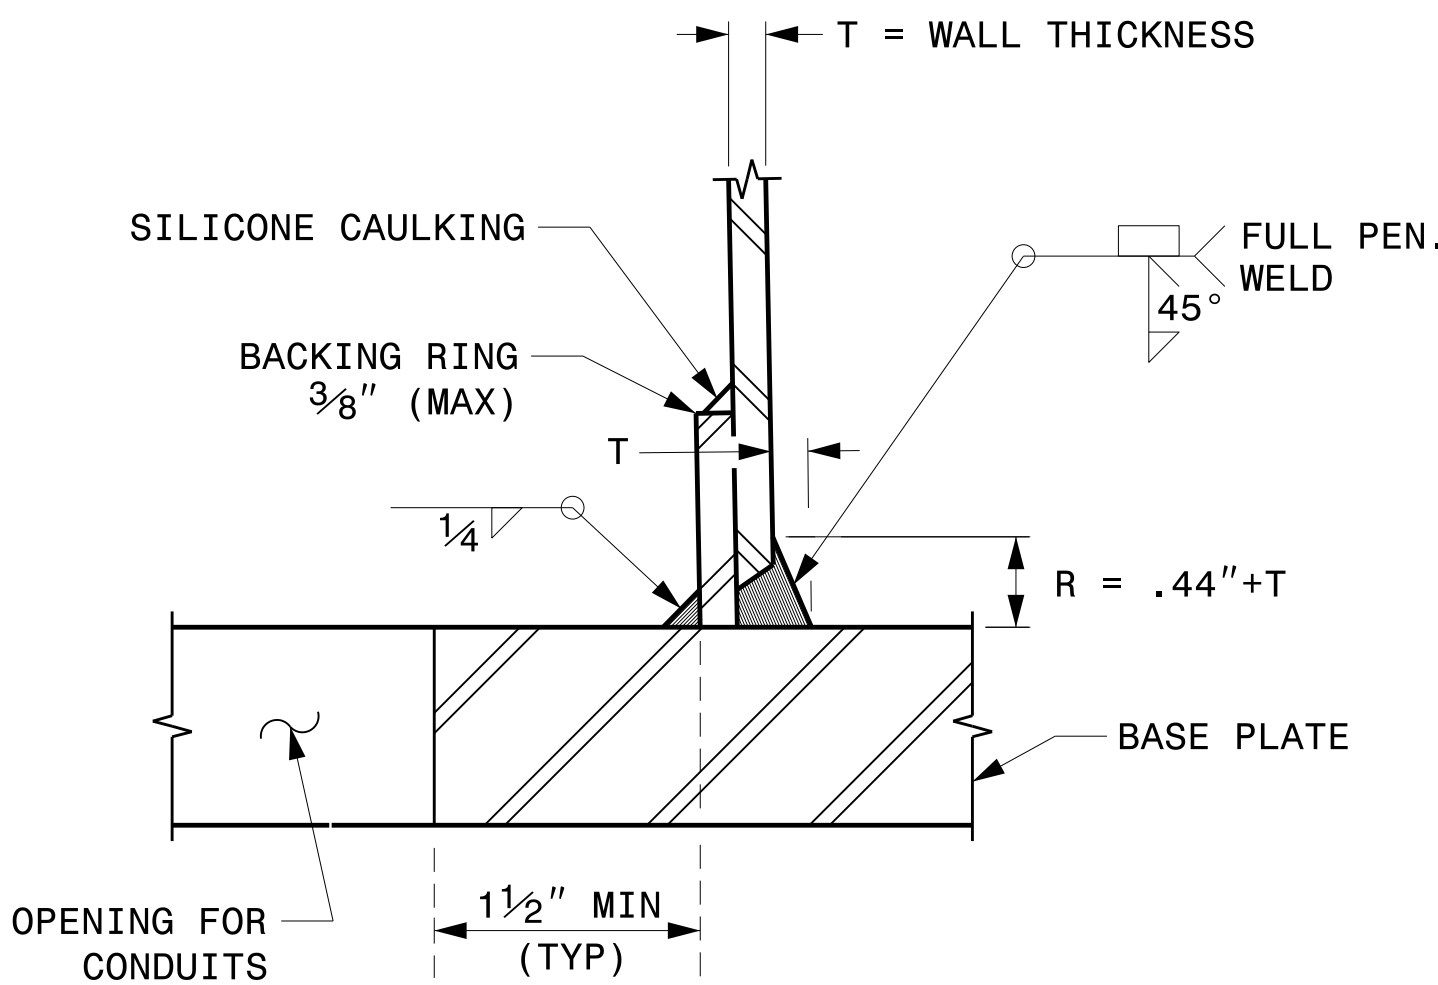

SECTION C-C



(POLE ATTACHMENT TO BASE PLATE)

FULL-PENETRATION GROOVE WELD DETAIL

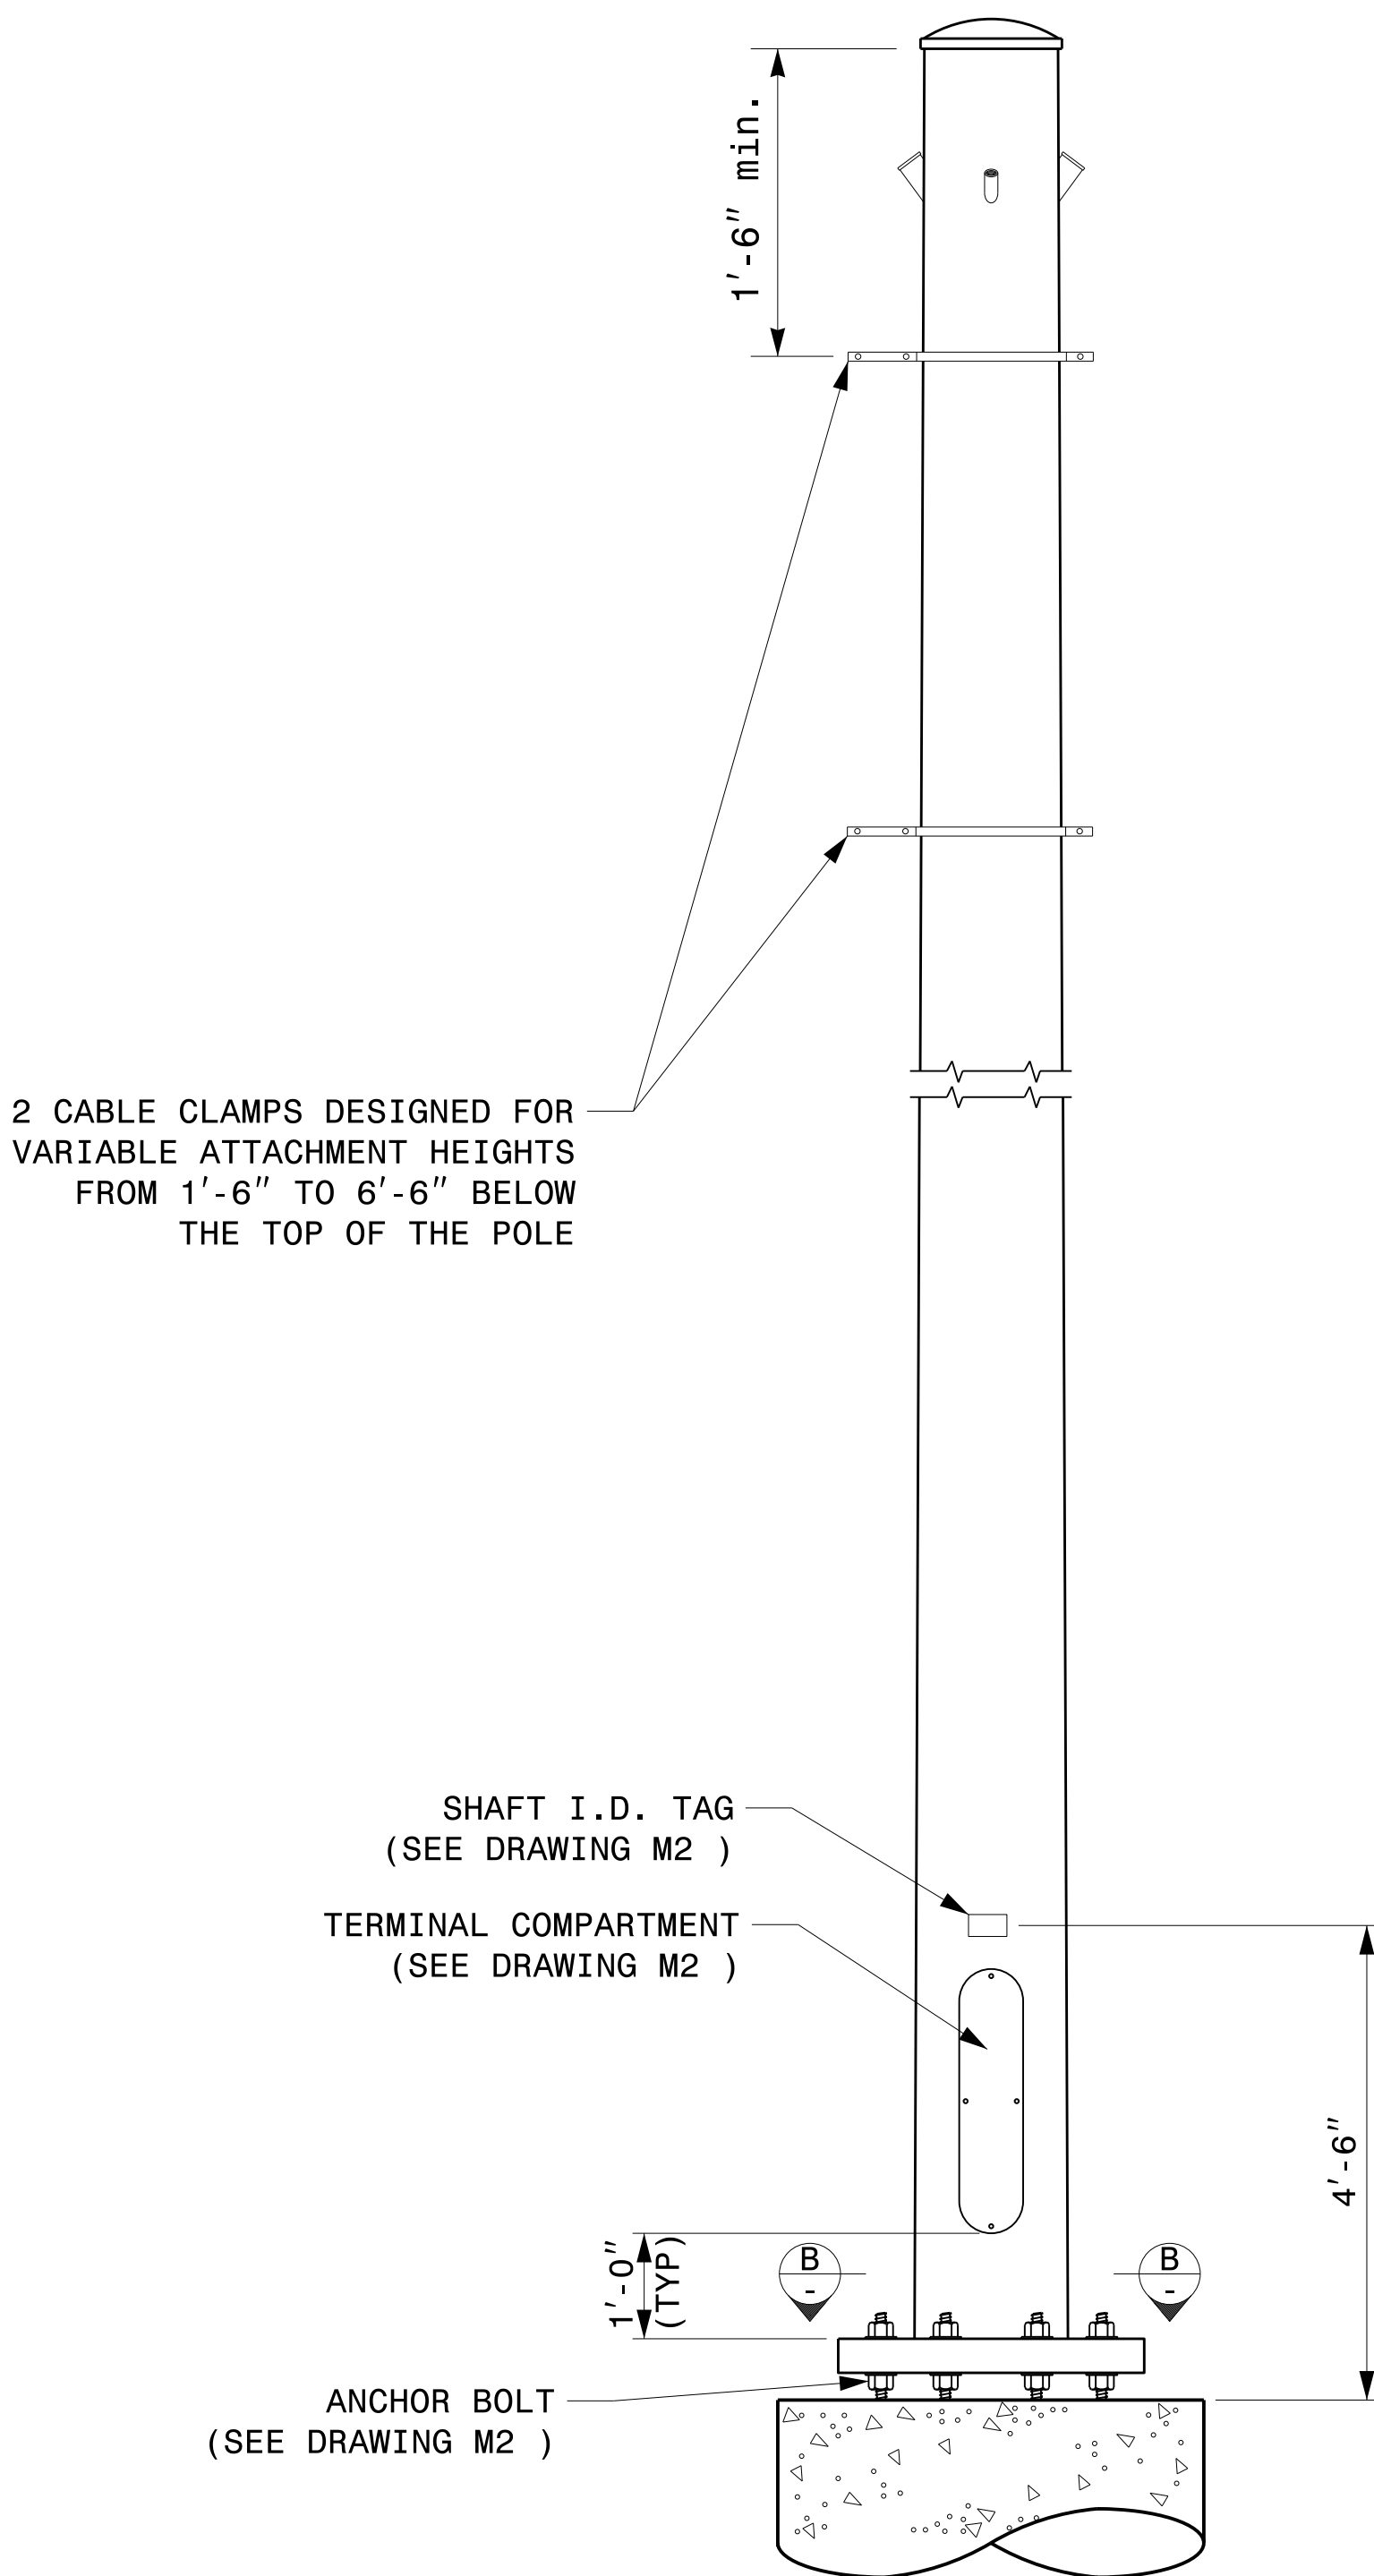

MONOTUBE STRAIN POLE

1. OPENING IN POLE BASE PLATE SHALL BE EQUAL TO POLE BASE INSIDE DIAMETER MINUS $3\frac{1}{2}$ " BUT SHALL NOT BE LESS THAN $8\frac{1}{2}$ ".

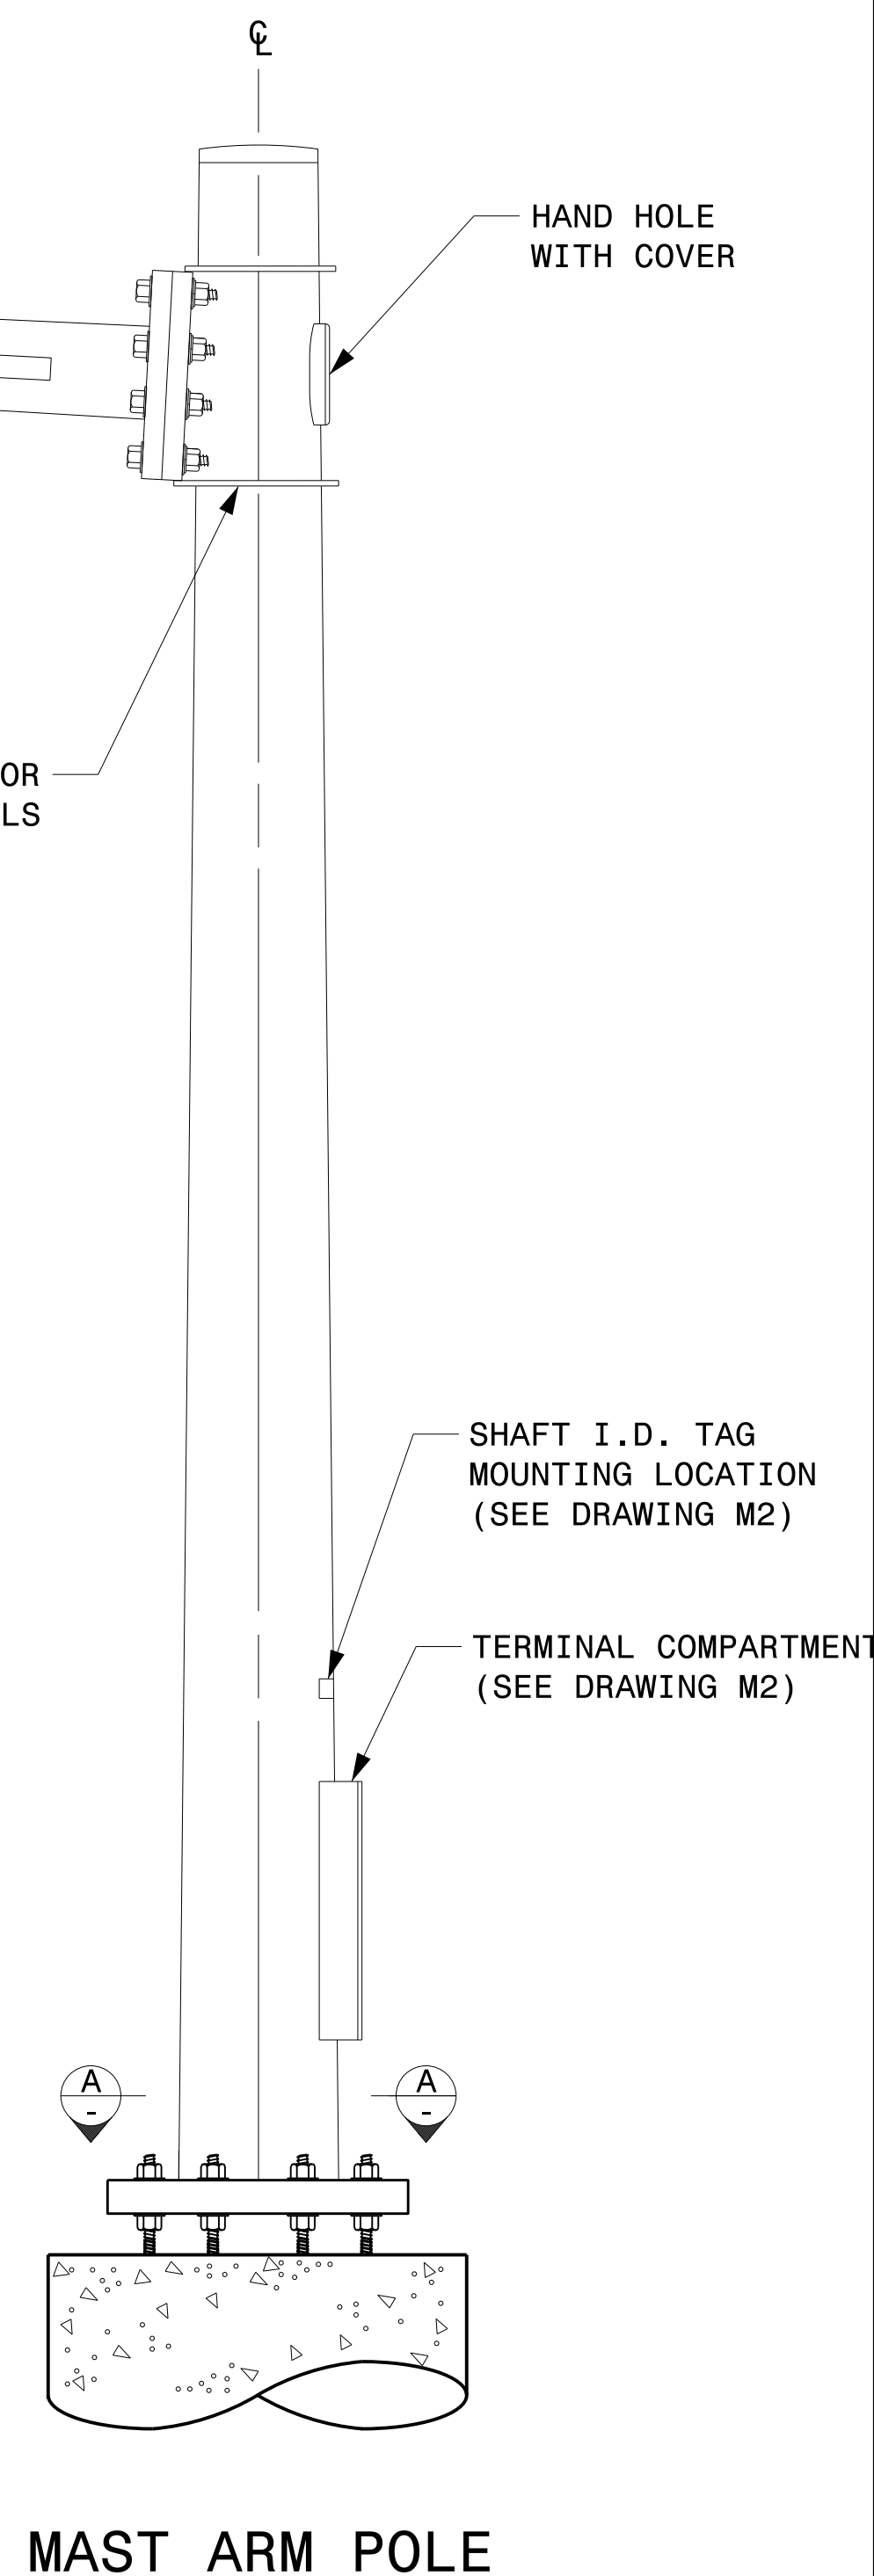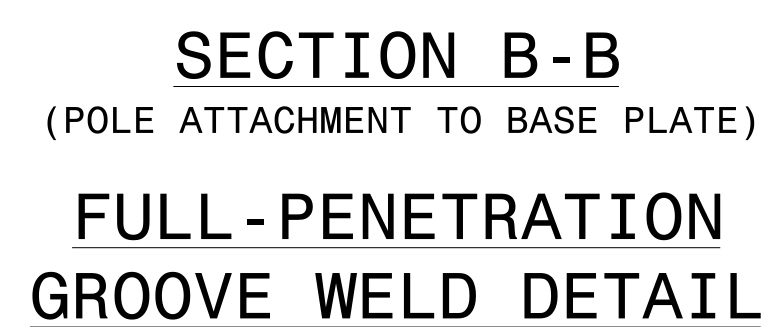


WELDED RING STIFFENED MAST ARM CONNECTION


PROJECT I.D. NO.

SHEET NO.


Sig.M5

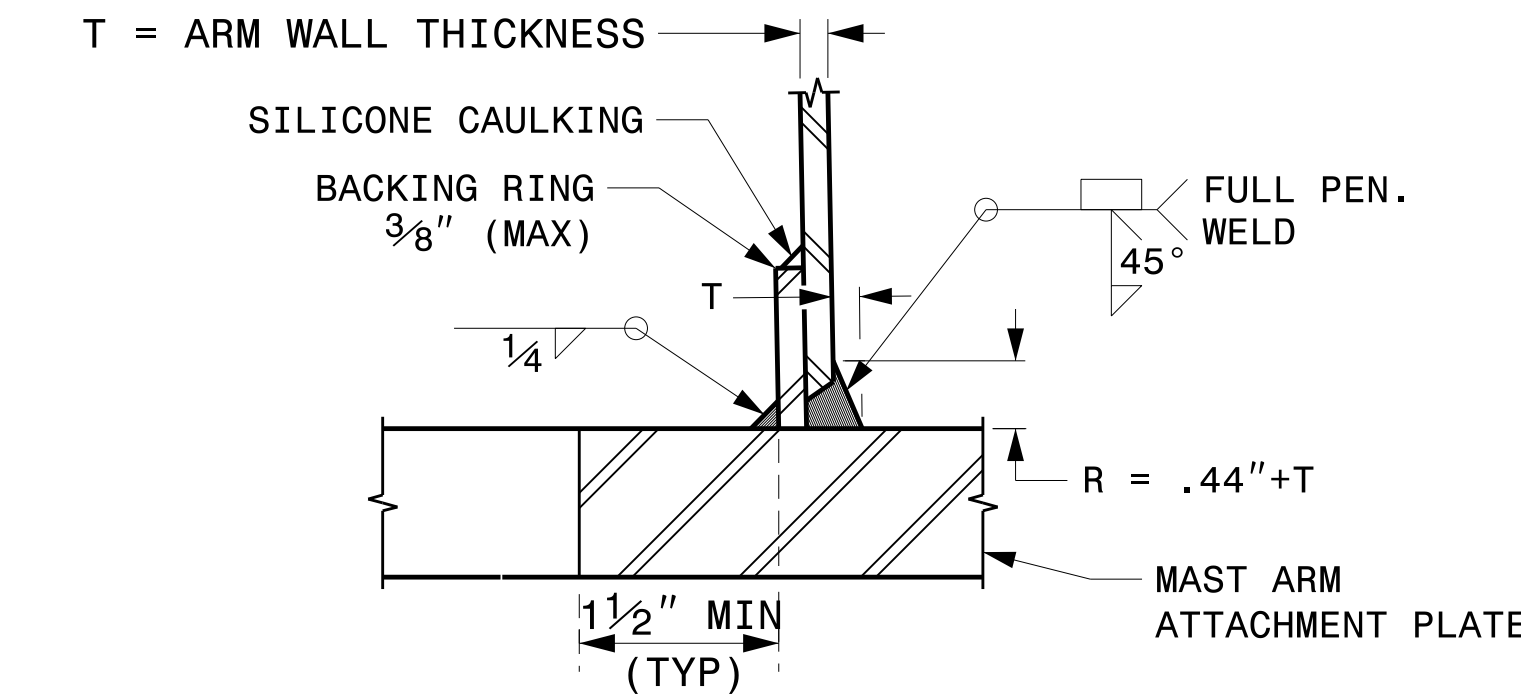


SECTION B-B
FULL-PENETRATION GROOVE WELD DETAIL

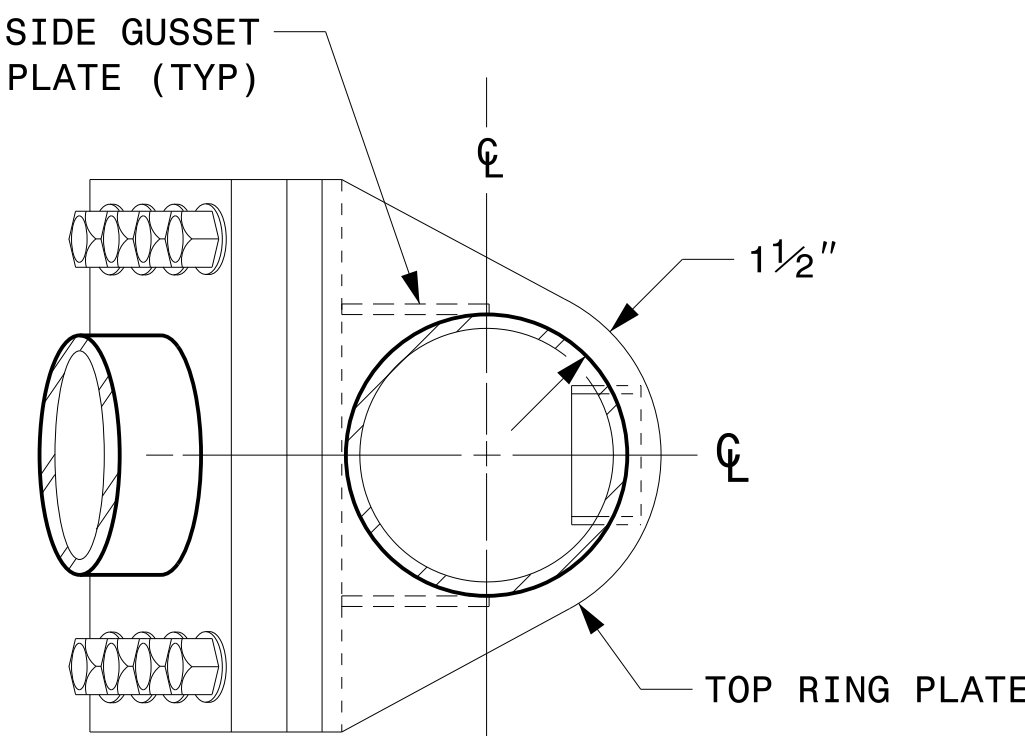


PLAN VIEW

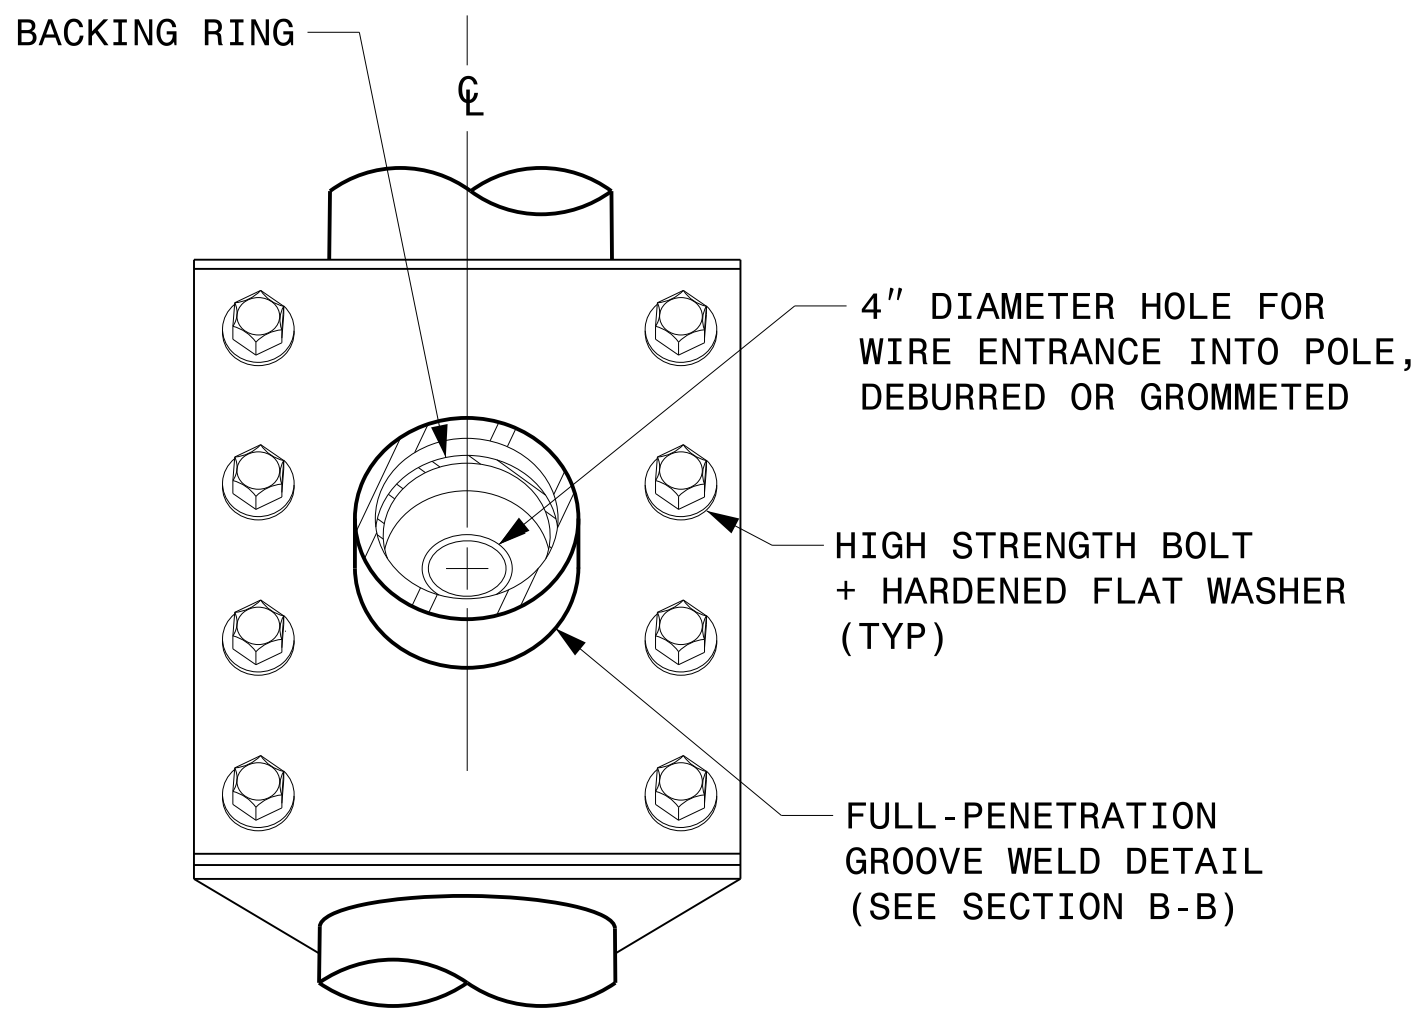


FRONT ELEVATION VIEW

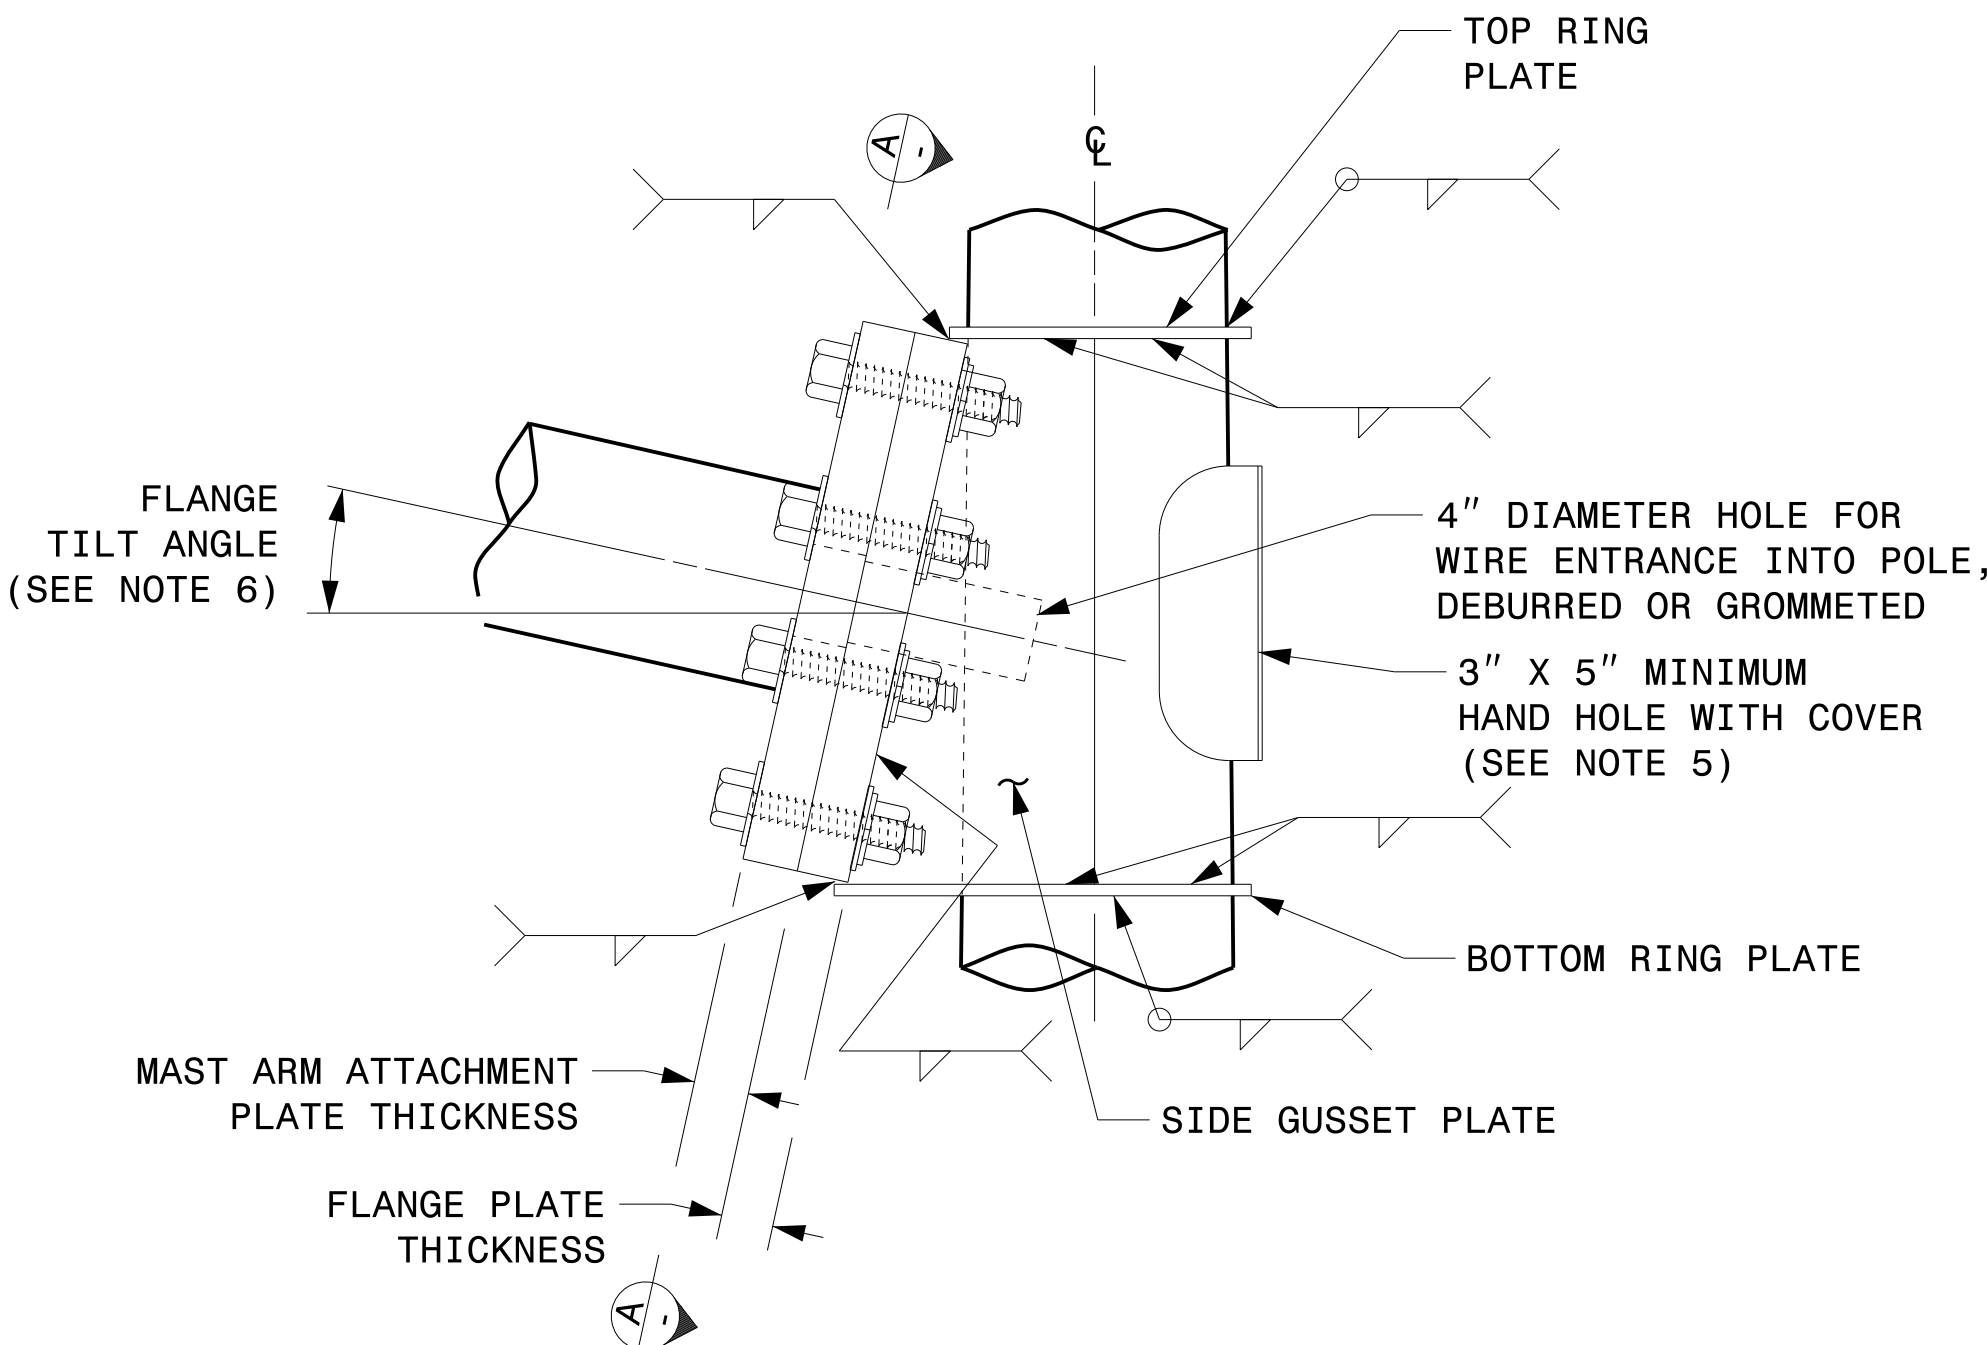


SIDE ELEVATION VIEW

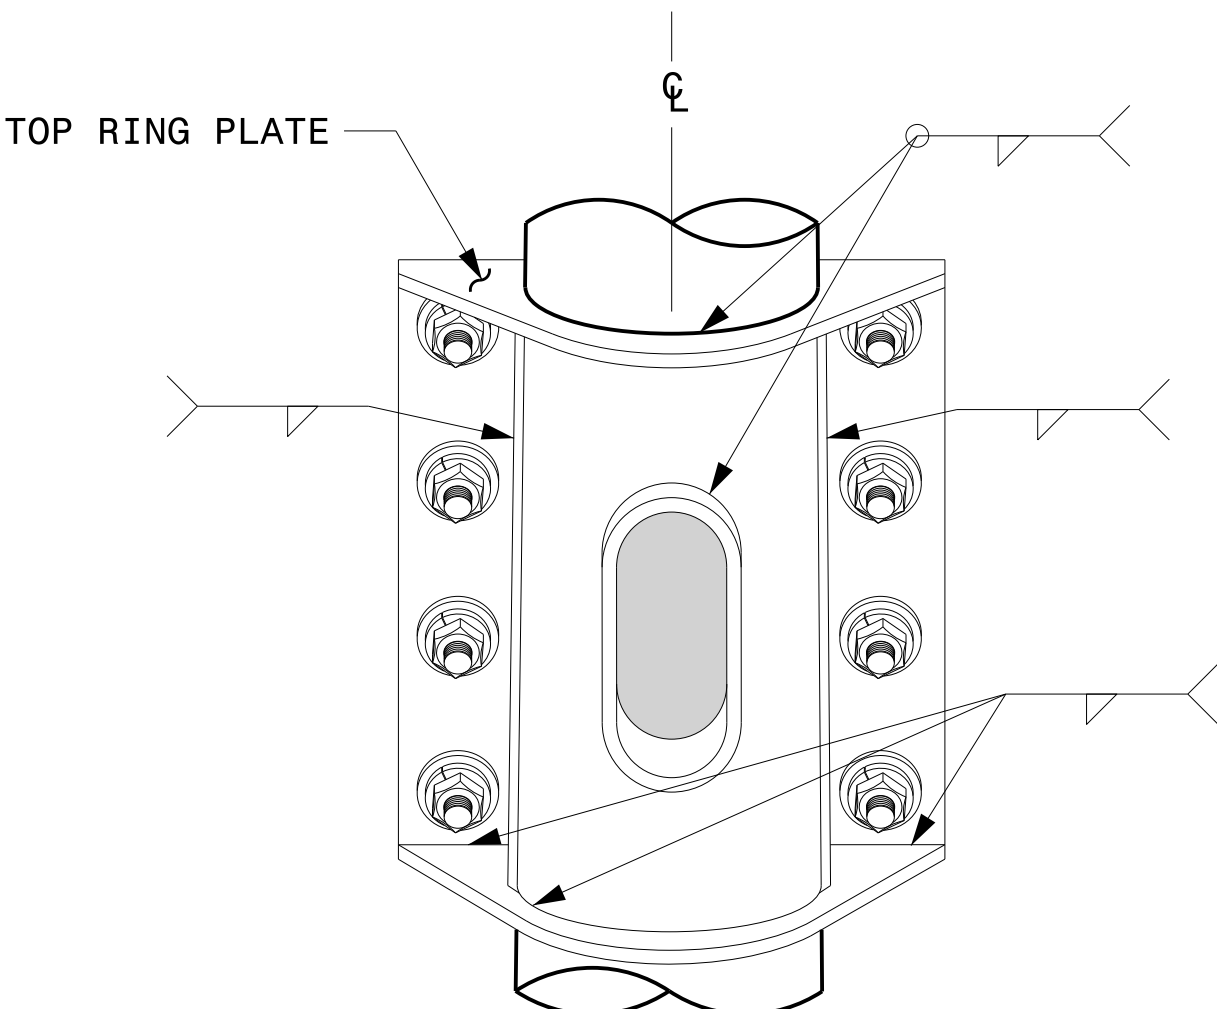

BACK ELEVATION VIEW

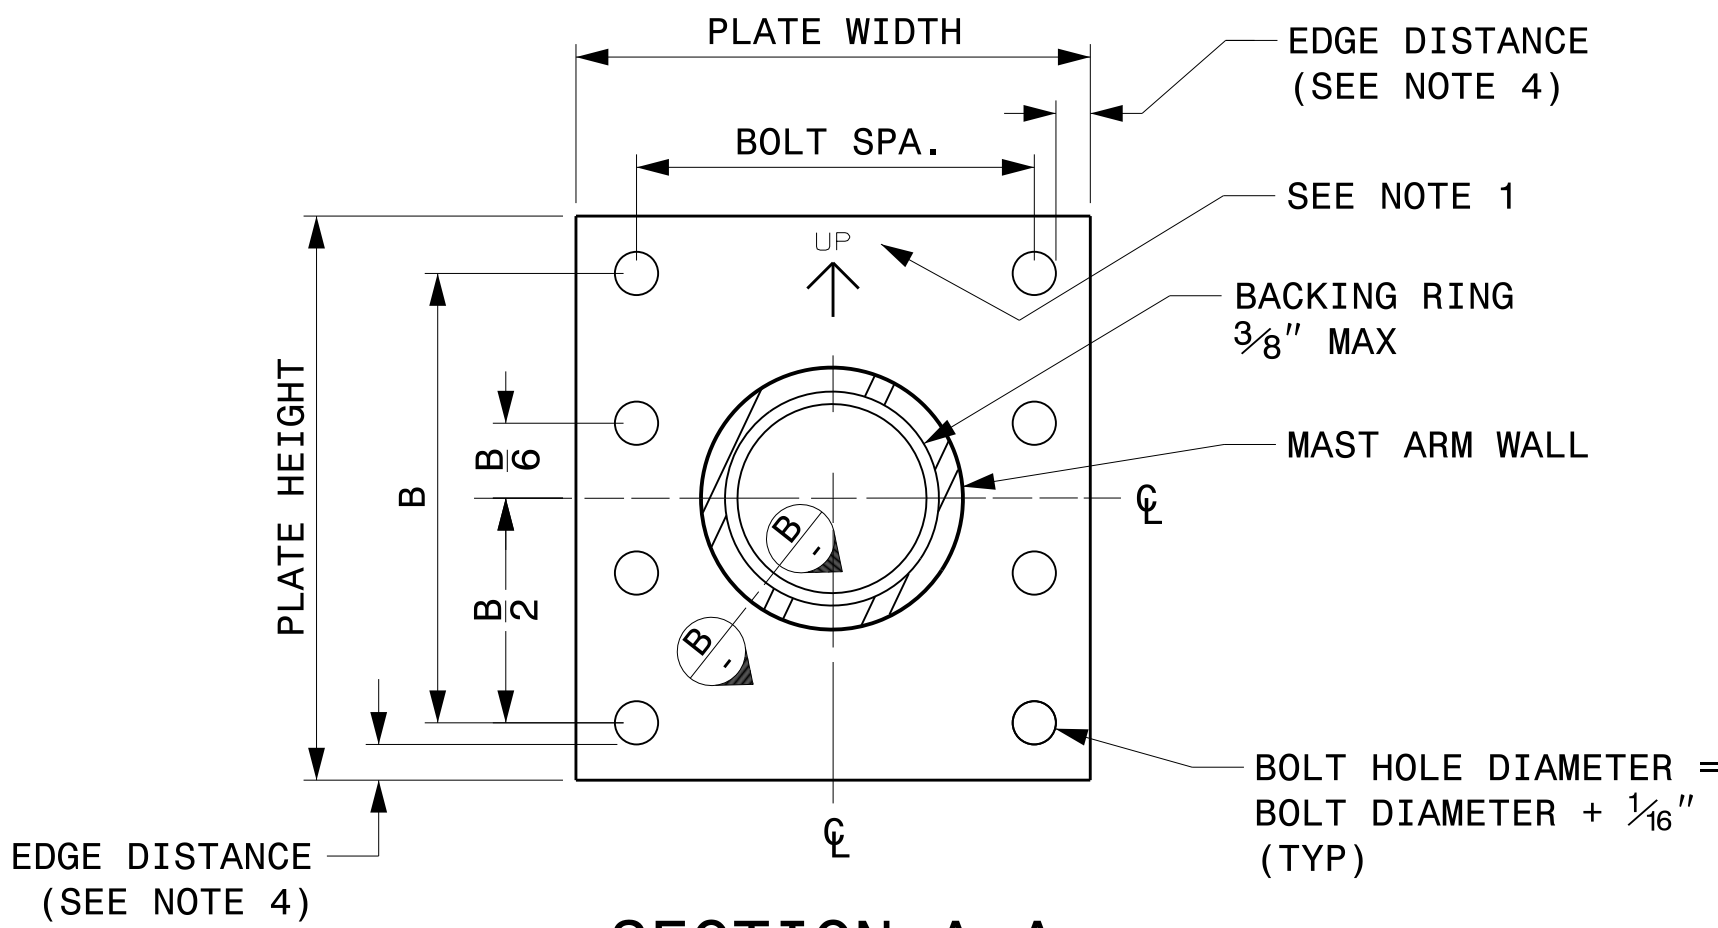

SECTION A-A
MAST ARM ATTACHMENT PLATE

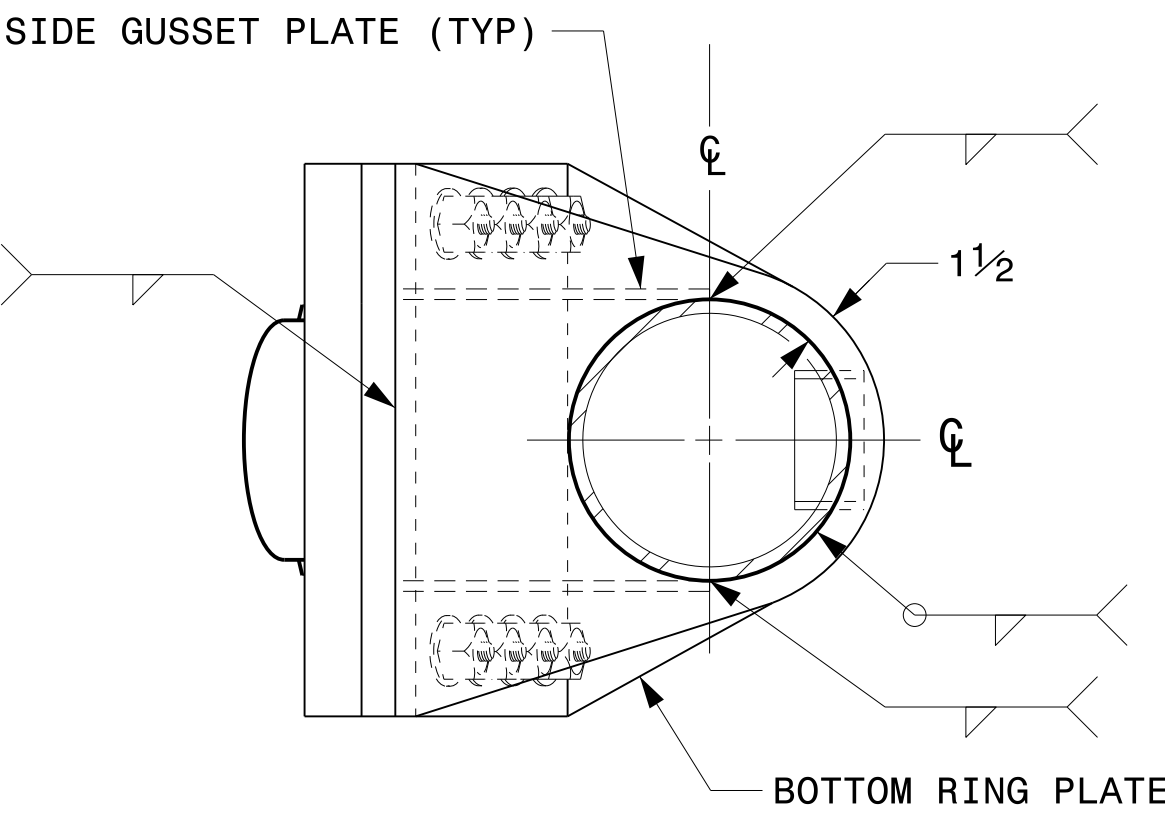

BOTTOM VIEW


NOTES:

1. PROVIDE A PERMANENT MEANS OF IDENTIFICATION ABOVE THE MAST ARM TO INDICATE PROPER ATTACHMENT ORIENTATION OF THE MAST ARM.
2. DESIGNER WILL DETERMINE THE SIZE OF ALL STRUCTURAL COMPONENTS, PLATES, FASTENERS, AND WELDS SHOWN UNLESS THEY ARE ALREADY SPECIFIED.
3. FABRICATOR IS RESPONSIBLE FOR PROVIDING APPROPRIATE HOLES AT DRAINAGE POINTS TO DRAIN GALVANIZING MATERIALS.
4. FOR MINIMUM EDGE DISTANCE AND NOMINAL BOLT HOLE SIZE, FOLLOW THE LATEST AISC STEEL CONSTRUCTION MANUAL.
5. PROVIDE UPPER HANDHOLE AS NECESSARY WHEN SHAFT EXTENSIONS ARE REQUIRED FOR LUMINAIRE ARMS OR CAMERA. FOR POLES WITHOUT LUMINAIRES/CAMERA, WIRING CAN BE DONE THROUGH THE TOP OF POLE.
6. ALLOWABLE RANGE OF FLANGE TILT ANGLE WILL VARY FROM 0° TO AS REQUIRED.

	Typical Fabrication Details For Mast Arm Connection To Pole		
	PLAN DATE: SEPTEMBER 2023	DESIGNED BY: C.F. ANDREWS	
PREPARED BY: K.C. DURIGON	REVIEWED BY: D.C. SARKAR	INIT.	DATE
REVISIONS		INIT.	DATE
0 NA			
NONE			


DocuSigned by:
Kevin Durigon
4B23DC79B3784DA...

09/21/2023
DATE

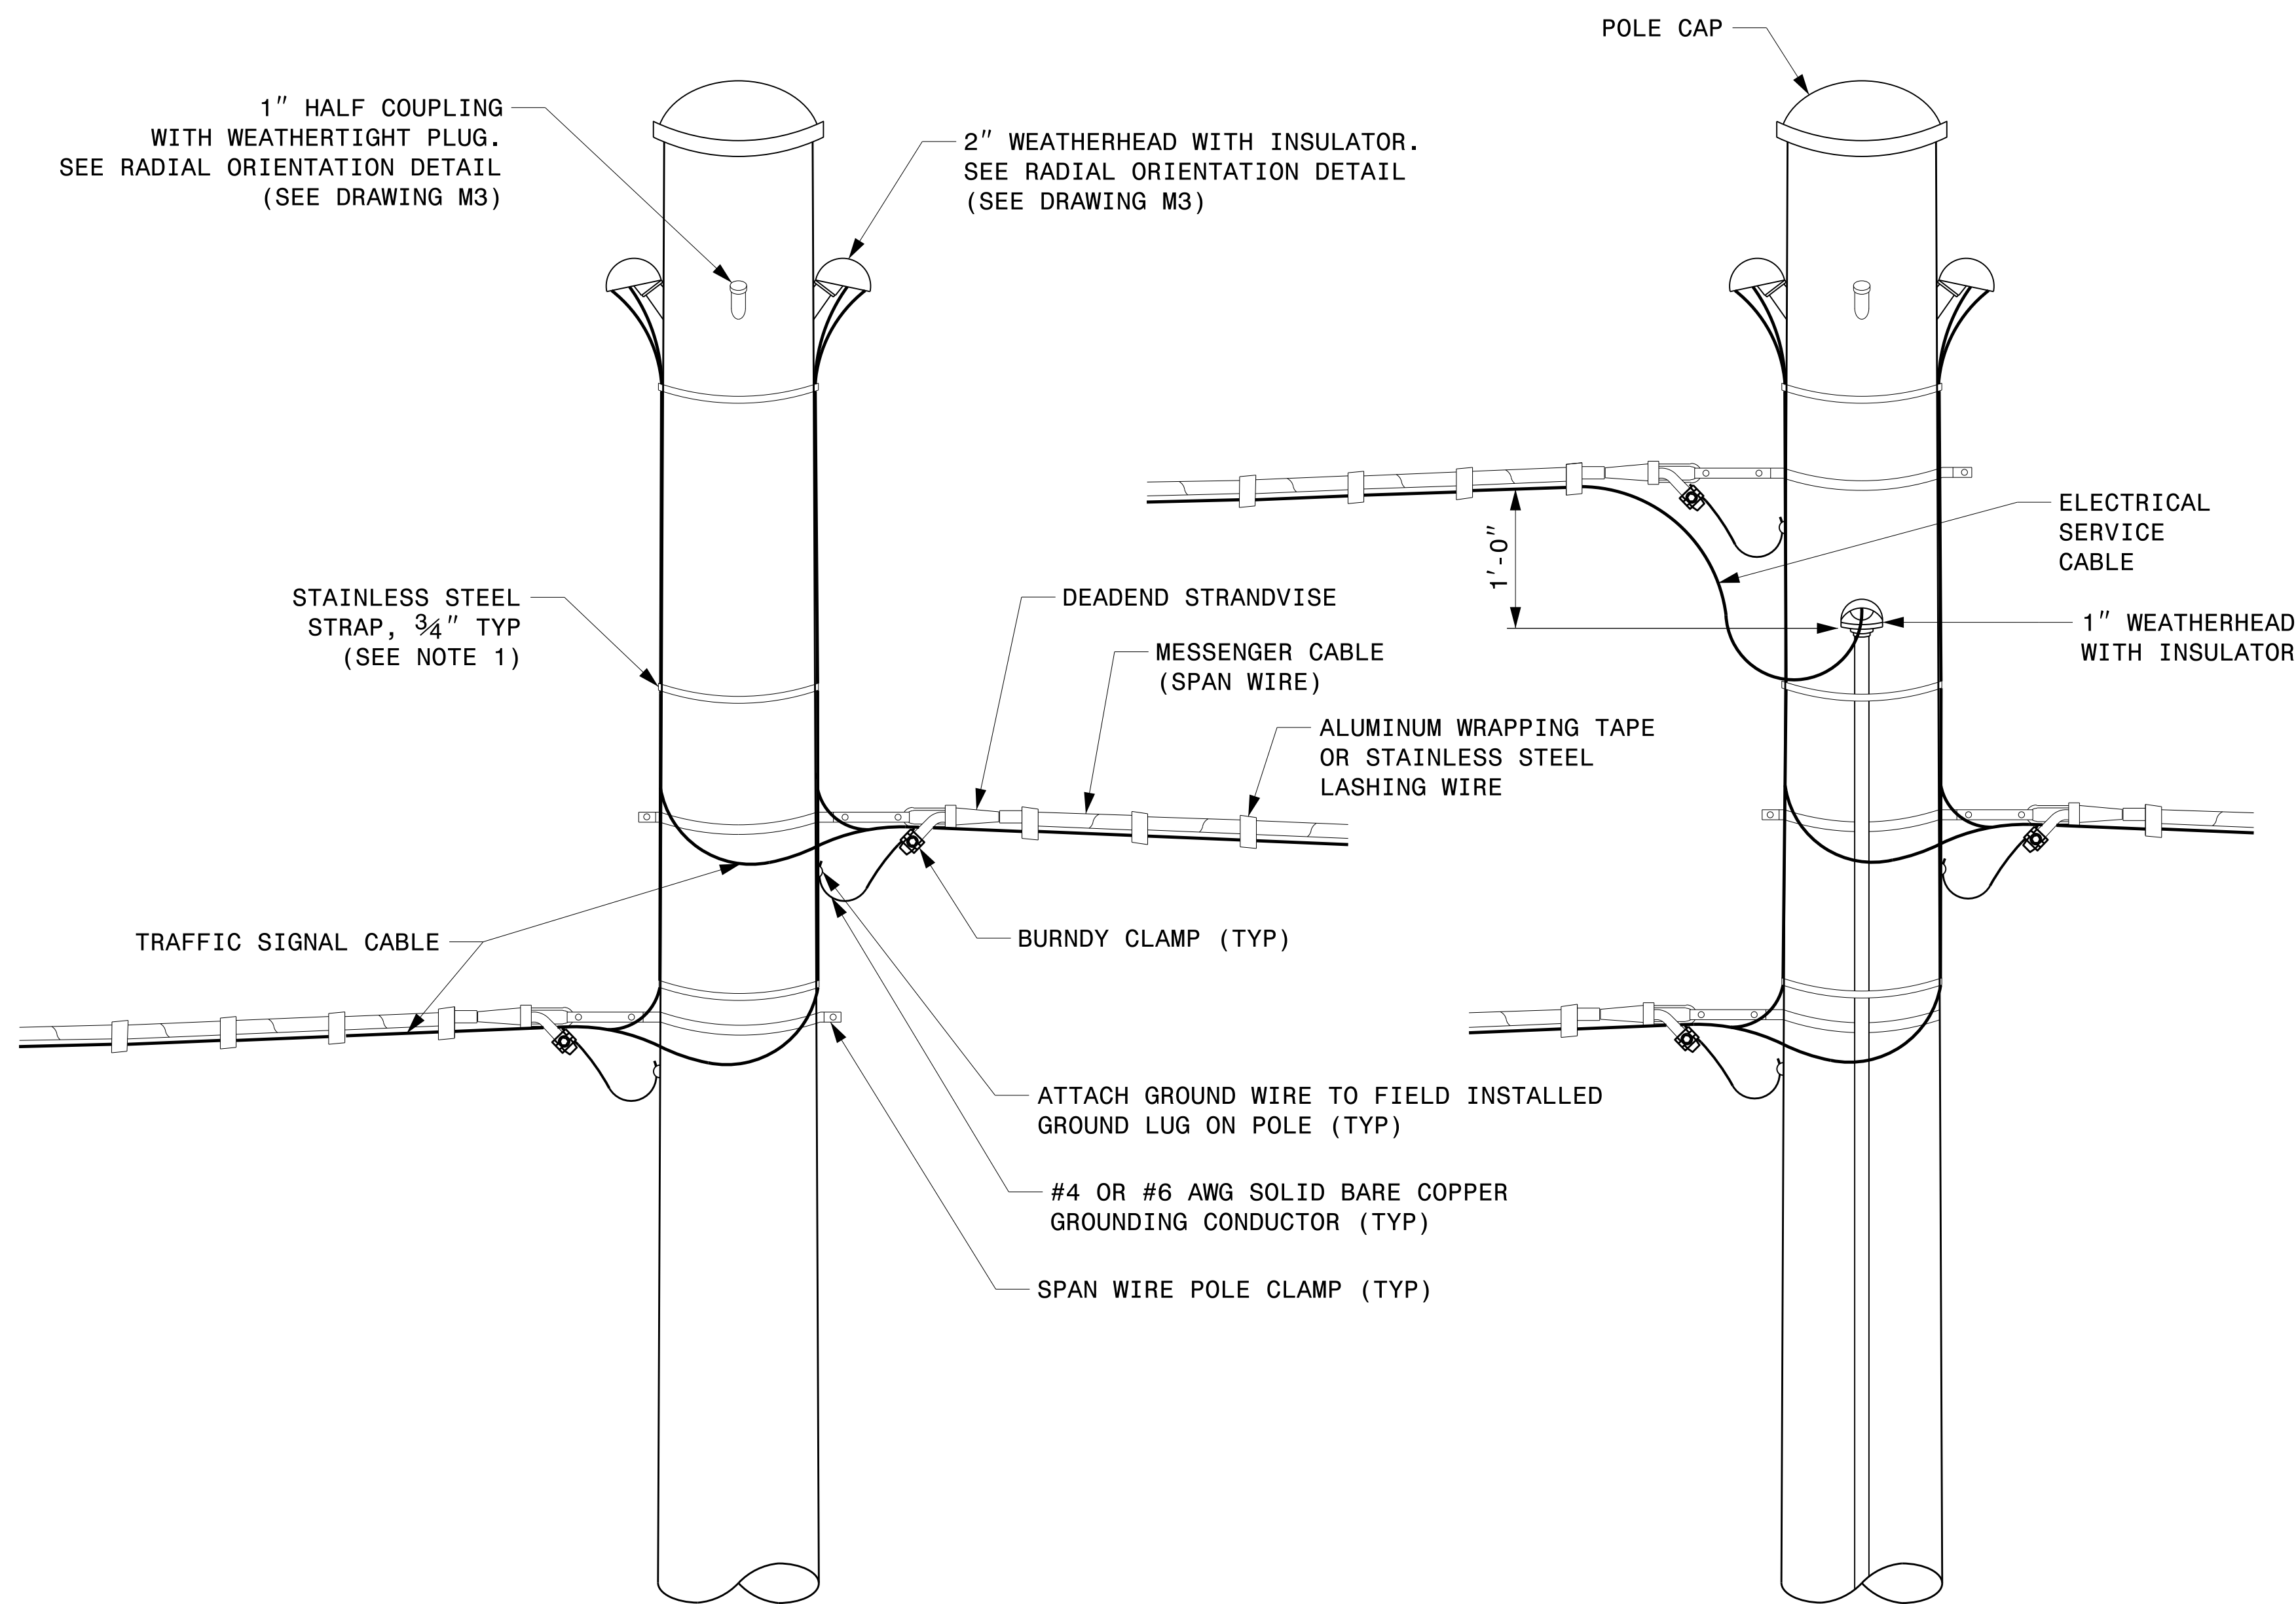


STRAIN POLE ATTACHMENTS



- NOTES:
- STRAP ALL SIGNAL CABLES TO THE SIDE OF THE POLE WITH 3/4" STAINLESS STEEL STRAPS WHEN THE DISTANCE BETWEEN SPAN WIRE ATTACHMENT CLAMP AND WEATHERHEADS EXCEEDS 3'-0".
 - PROVIDE MINIMUM TWO SPAN WIRE POLE CLAMPS PER POLE.
 - IT IS PROHIBITED TO ATTACH TWO SPAN WIRES AT ONE POLE CLAMP.
 - FOR GENERAL REQUIREMENTS, REFER TO NCDOT STANDARD SPECIFICATIONS FOR ROADWAY AND STRUCTURES, JANUARY 2024.

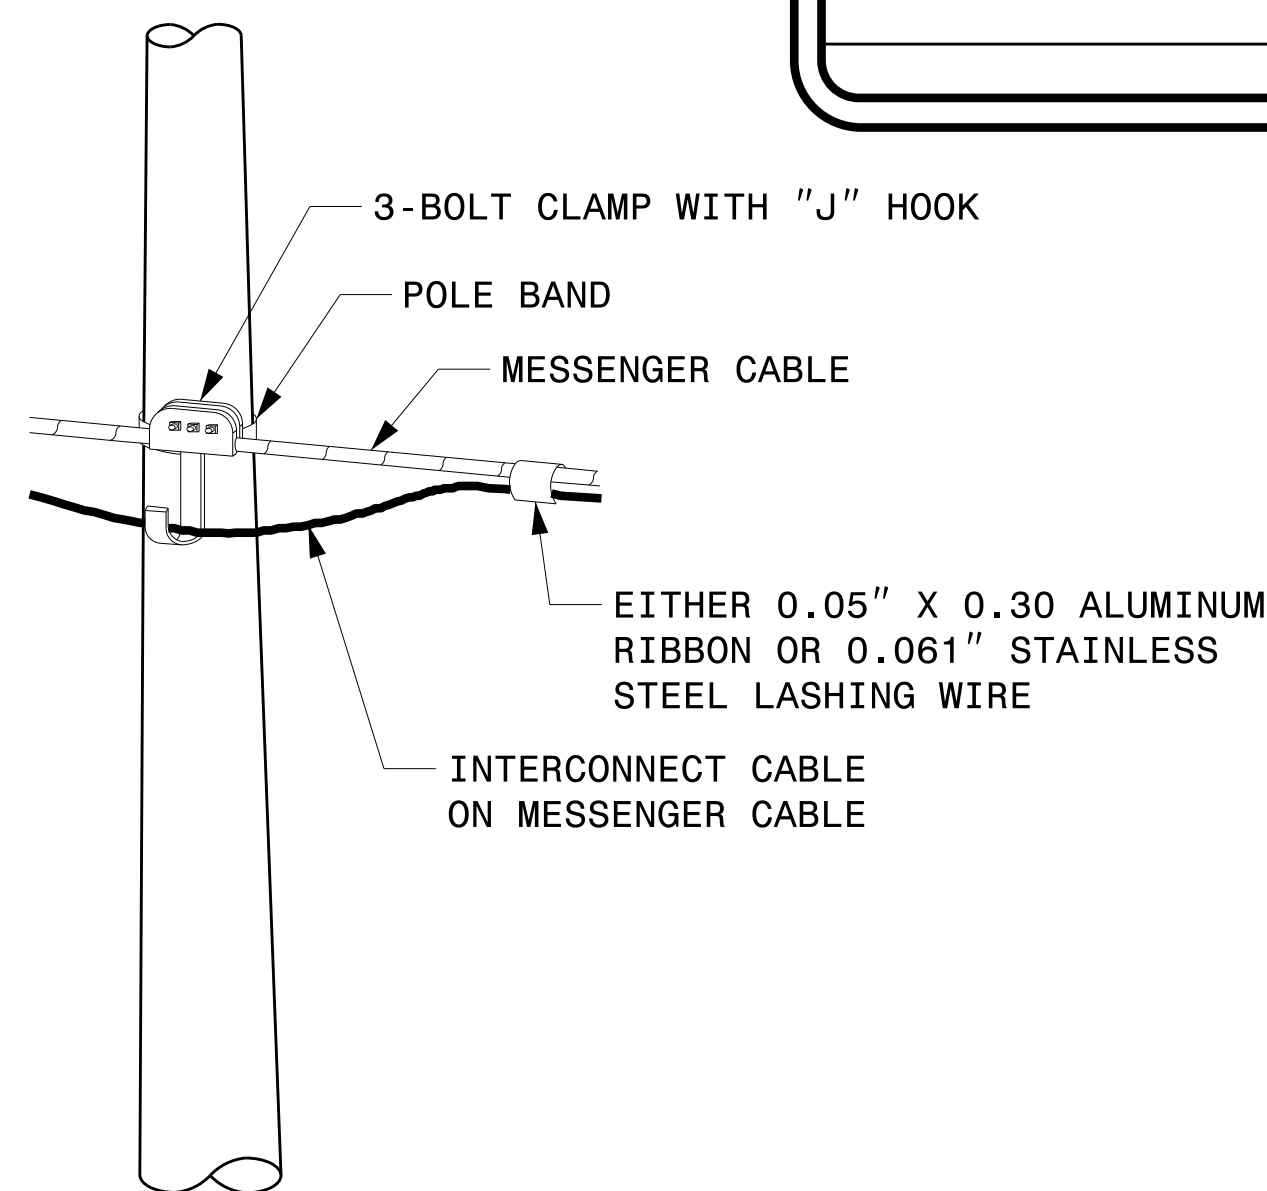

ATTACHMENT OF CABLE TO INTERMEDIATE METAL POLE

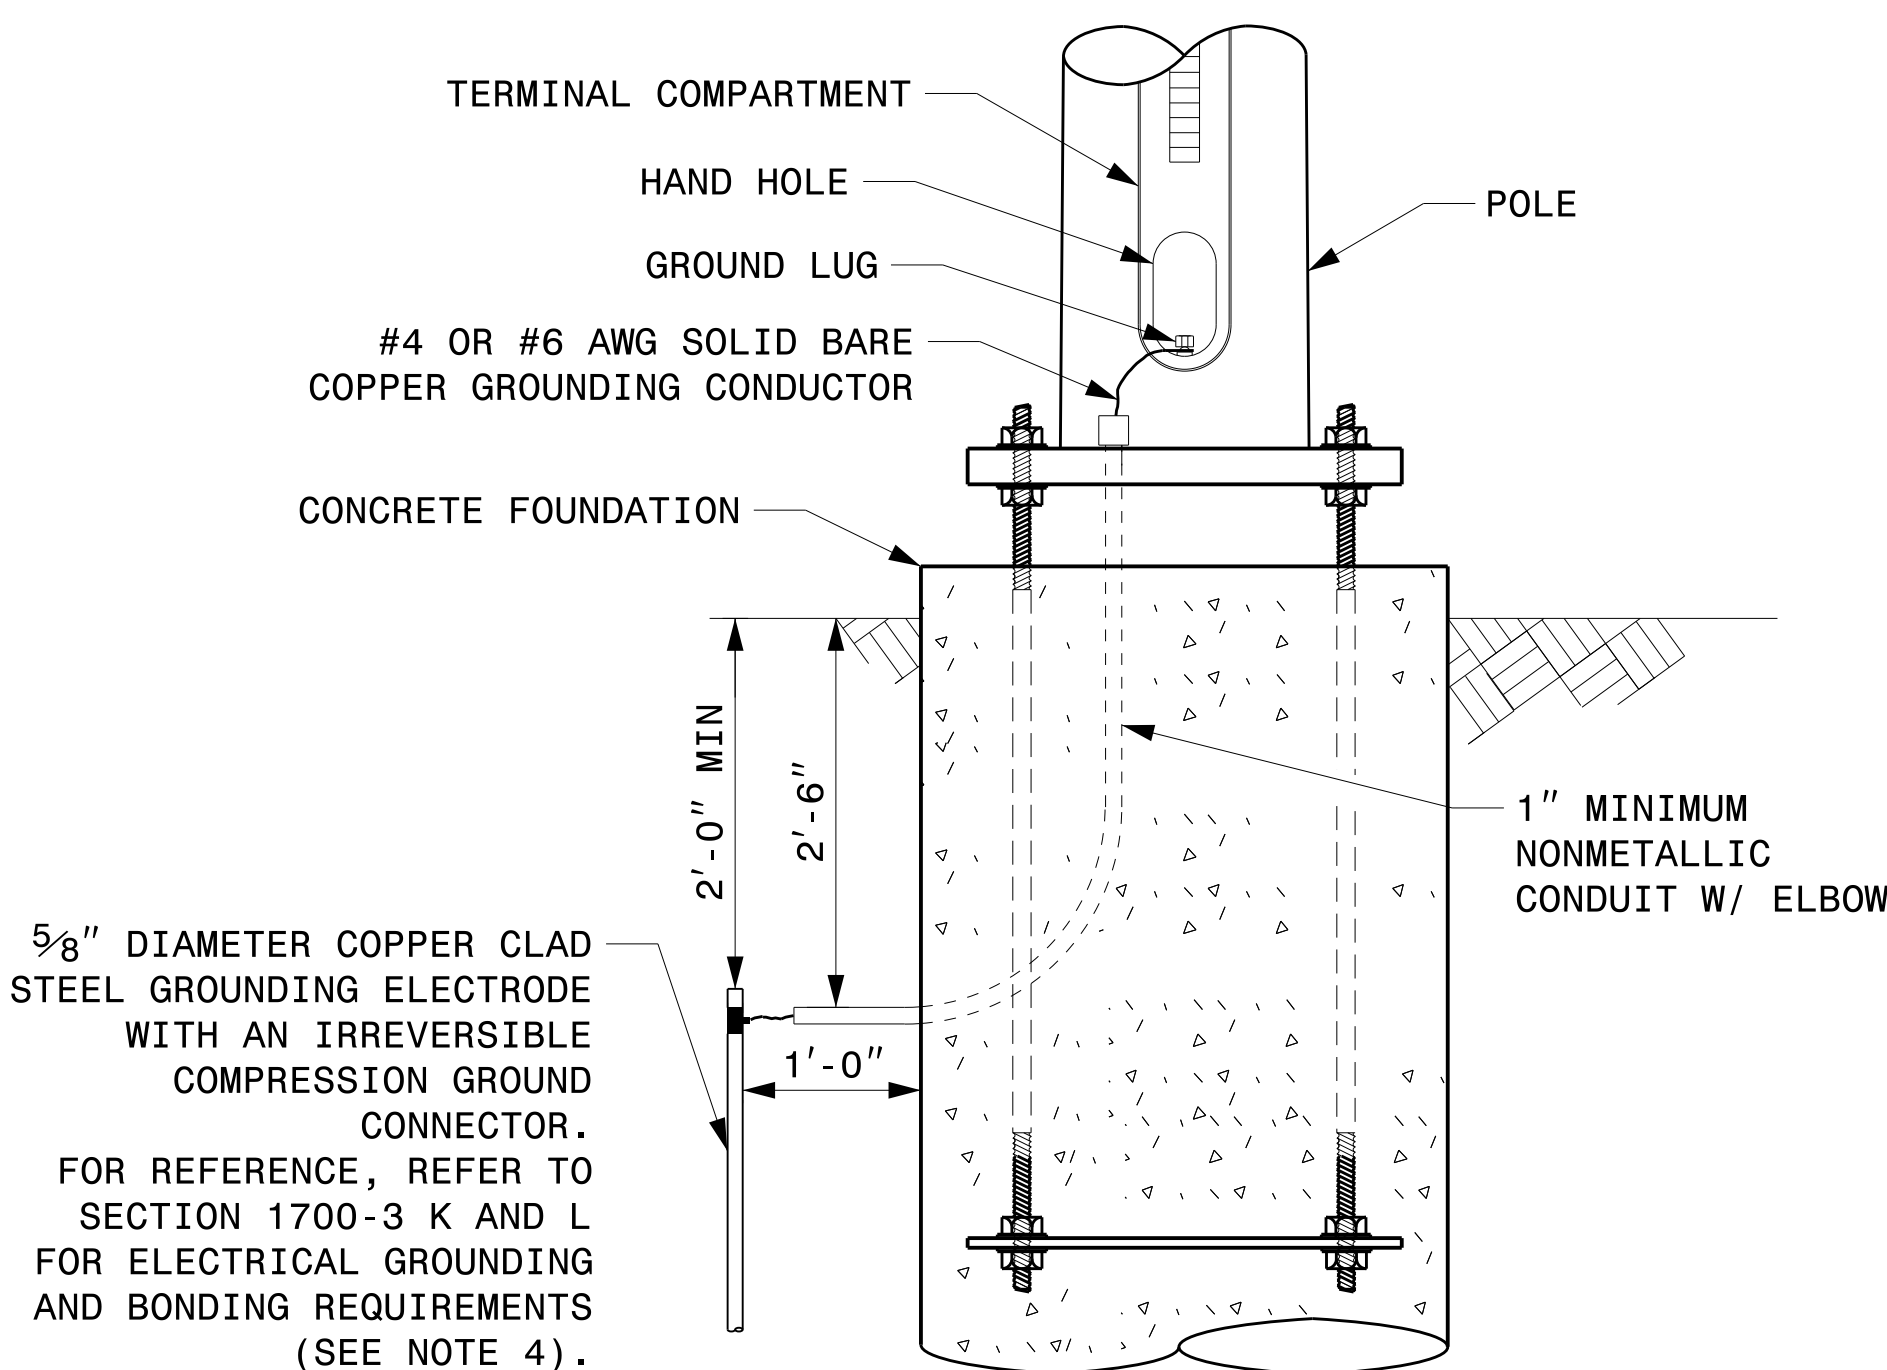

METAL POLE GROUNDING DETAIL FOR STRAIN POLE AND MAST ARM

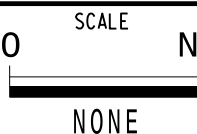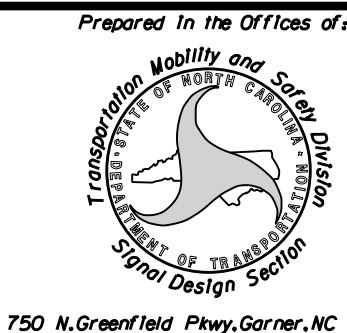

Typical Fabrication Details For Strain Pole Attachments			
PLAN DATE:	SEPTEMBER 2023	DESIGNED BY:	C.F. ANDREWS
PREPARED BY:	K.C. DURIGON	REVIEWED BY:	D.C. SARKAR
REVISIONS		INIT.	DATE

DocuSigned by:

Kevin Durigon

4B23DC79B3784DA...


SEAL

ENGINEER
KEYVIN C. DURIGON


09/21/2023

DATE


03-dpt-2023 19x41
S:\175551415 Signal\Signal Design Section\Structures\Drawings\2024 Metal Pole Stru. Fabrication Details-Strain Poles.dgn
Kedurigon

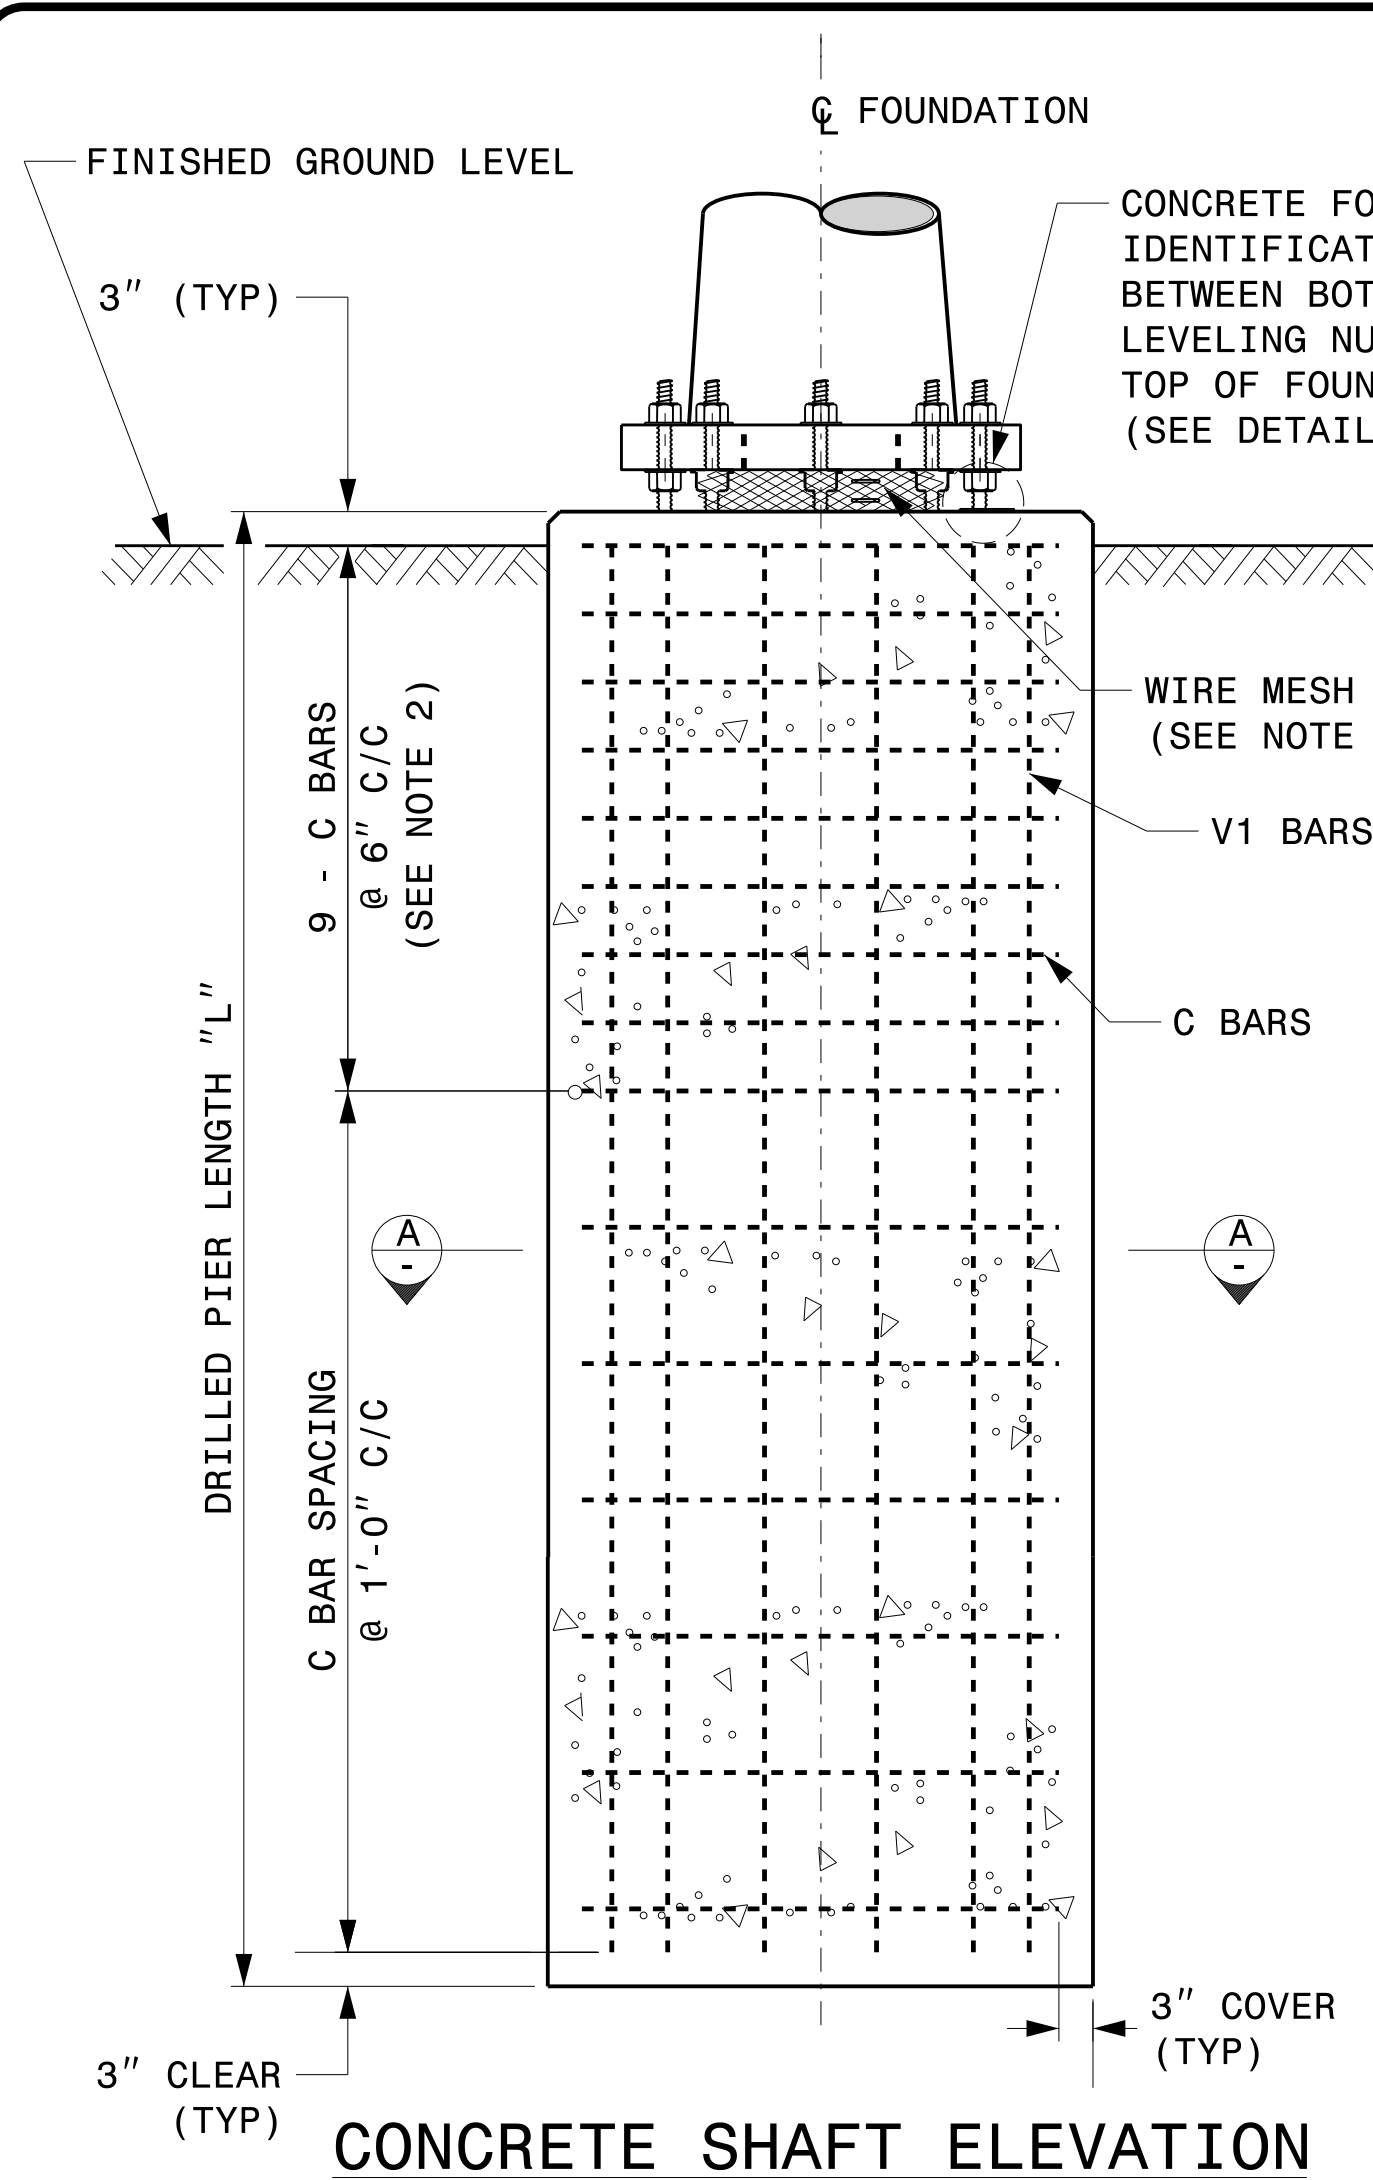


CONCRETE SHAFT ELEVATION

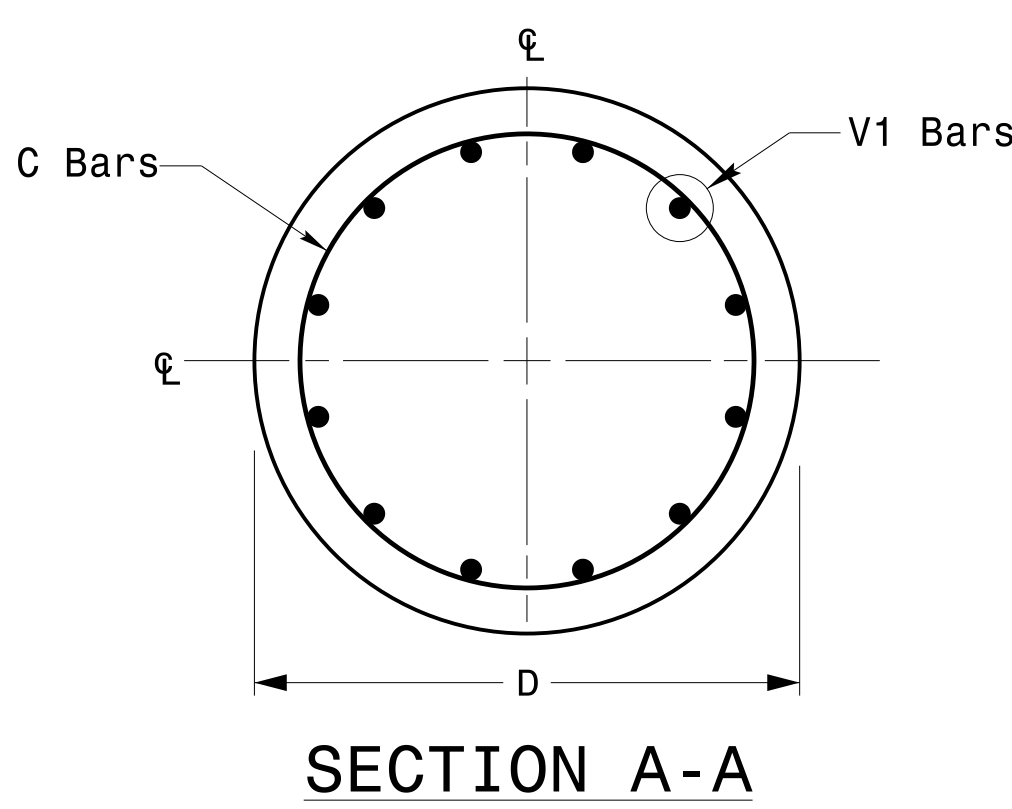

SECTION A-A

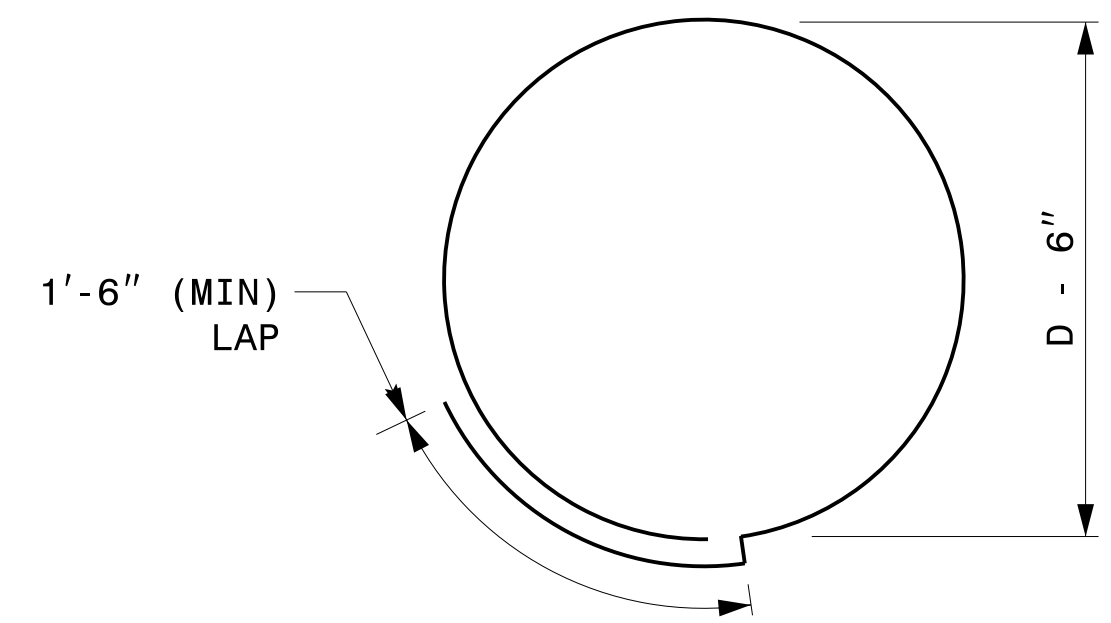

TYPICAL "C" BAR DETAIL

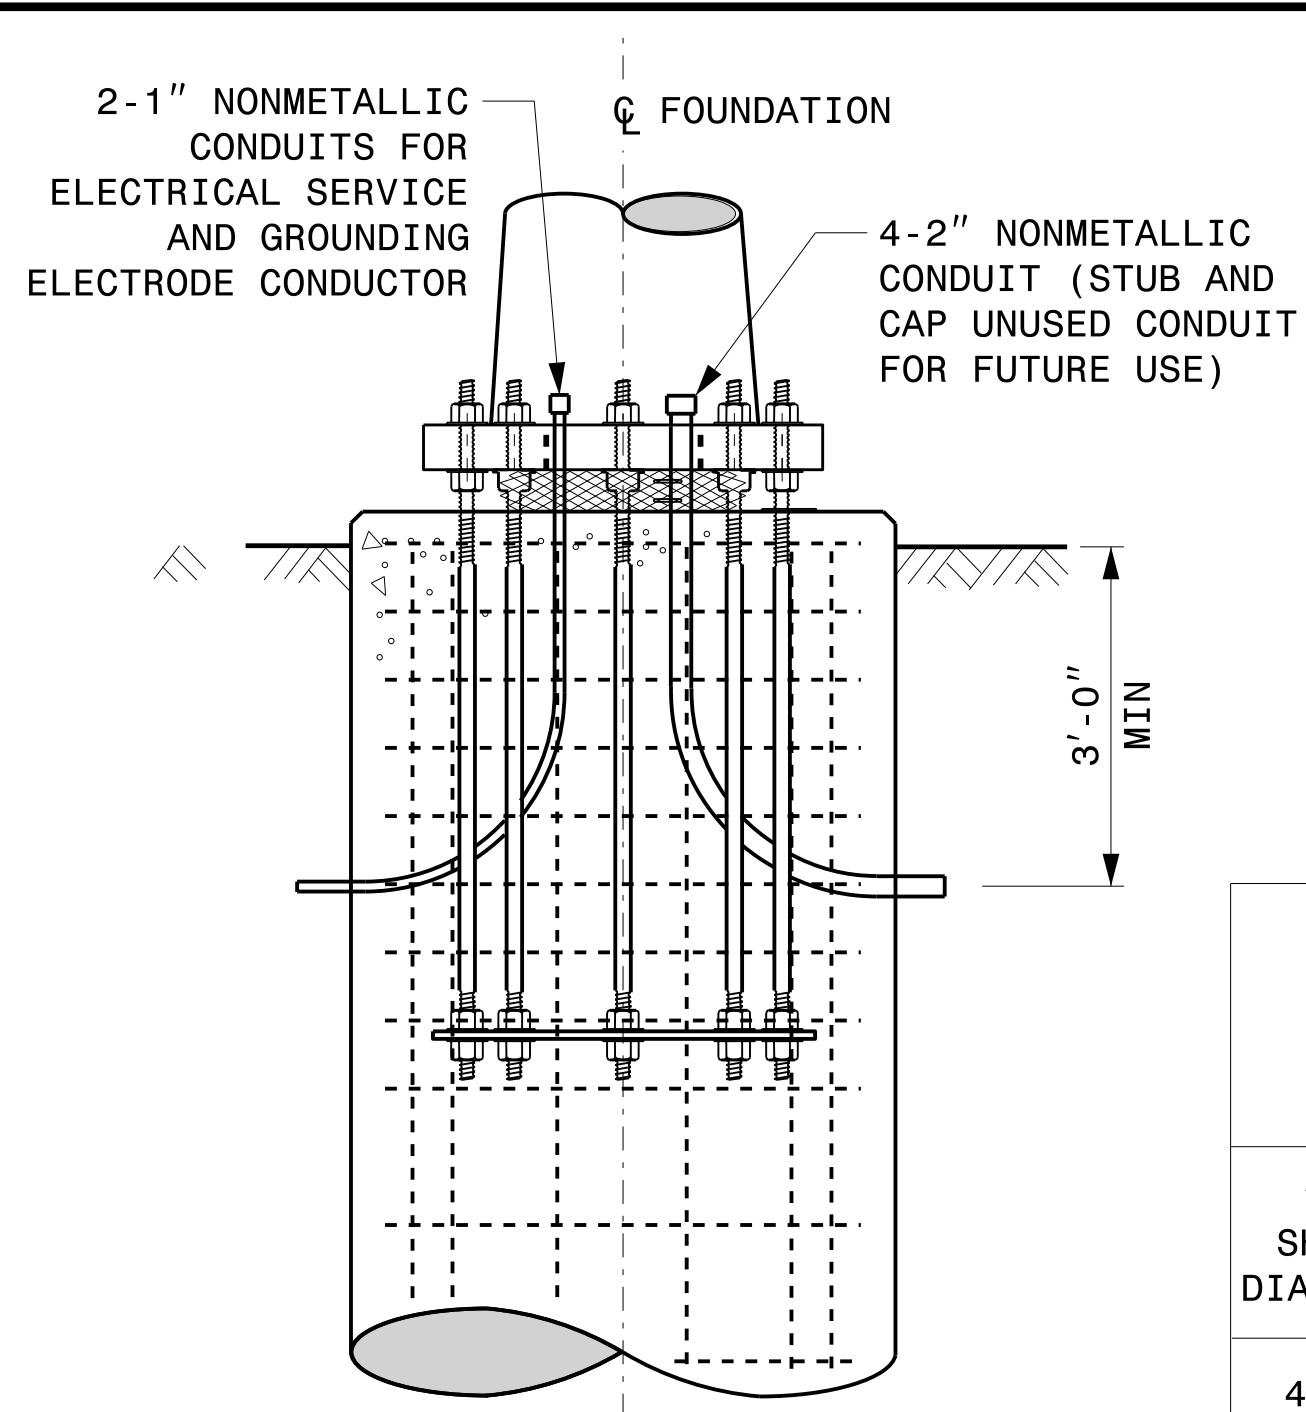


TYPICAL FOUNDATION CONDUIT DETAILS

GENERAL NOTES:


- IF ACTUAL SUBSURFACE CONDITIONS DIFFER SIGNIFICANTLY FROM BORING DATA, CONTACT THE ENGINEER BEFORE EXCAVATING OR PLACING CONCRETE.
- CIRCULAR TIE REINFORCING RINGS MAY BE VERTICALLY ADJUSTED BY +/-3" AT A DEPTH BETWEEN 2'-0" AND 3'-0" TO FACILITATE THE INSTALLATION OF ELECTRICAL CONDUIT ENTERING IN THE CAGE.
- FOR STANDARD FOUNDATIONS, SEE SHEET SIG. M8 FOR DETAILS. VERTICAL REINFORCING BARS (V1) MAY BE HORIZONTALLY ADJUSTED BY +/-3" TO FACILITATE THE INSTALLATION OF ELECTRICAL CONDUIT ENTERING INTO THE CAGE.
- PROVIDE 2" TO 5" FOUNDATION PROJECTION ABOVE GROUND LEVEL, DEPENDING ON THE GROUND SLOPE.
- UNLESS OTHERWISE SHOWN, FOUNDATION DESIGNS ARE BASED ON NON-SLOPING LEVEL GROUND SURFACES WITH SLOPE RATIOS OF 8:1 (H:V) OR FLATTER. IF ACTUAL GROUND LINE SLOPES ARE STEEPER, CONTACT THE ENGINEER BEFORE EXCAVATING OR PLACING CONCRETE.
- CONSTRUCT FOUNDATIONS IN ACCORDANCE WITH NCDOT STANDARD PROVISIONS SP09 R005- FOUNDATIONS AND ANCHOR ROD ASSEMBLIES FOR METAL POLES. ALL APPLICABLE 2024 NCDOT STANDARD SPECIFICATIONS ARE REFERENCED IN THIS PROVISION. REFER TO THE NCDOT RESOURCES/SPECIFICATIONS PAGE LOCATED ON THE CONNECT NCDOT WEBSITE.
[https://connect.ncdot.gov/resources/Specifications and Special Provisions.aspx](https://connect.ncdot.gov/resources/Specifications%20and%20Special%20Provisions.aspx)
- USE AIR ENTRAINED AA CONCRETE MIX WITH A COMPRESSION STRENGTH OF f'c=4500 psi (MIN) AFTER 28 DAYS.
- USE ASTM A615 GRADE 60 DEFORMED BARS FOR ALL REINFORCING STEEL. MAINTAIN AT LEAST 3" COVER ON ALL REINFORCEMENT.
- LOCATE IDENTIFICATION TAG ON TOP OF THE FOUNDATION, DIRECTLY ABOVE THE CONDUIT'S ENTRY POINT.
- PROVIDE TWO LAYERS OF 4 MESH GALVANIZED WELDED 23 GAUGE (0.025) 6" WIDE AROUND PIPES UNDER THE BASE PLATE AND SECURE IT WITH TIES IF NECESSARY.
- PREFERRED LOCATION FOR THE I.D. TAG IS AS SHOWN IN DETAIL-A: DIRECTLY ABOVE THE CONDUIT ENTERING THE FOUNDATION.

REINFORCING STEEL TABLE FOR STANDARD DRILL PIER SHAFT (4'-0" DIAMETER)						
"D" SHAFT DIAMETER	CONCRETE VOLUME (CU. YDS)	BAR NAME	MIN. SIZE	TYPE	LENGTH	
4'-0"	.465 X L	V1	-	#8	STR.	**
		C	*	#4	CIR.	12'-6"

* SEE NOTE 2
** SEE NOTE 3

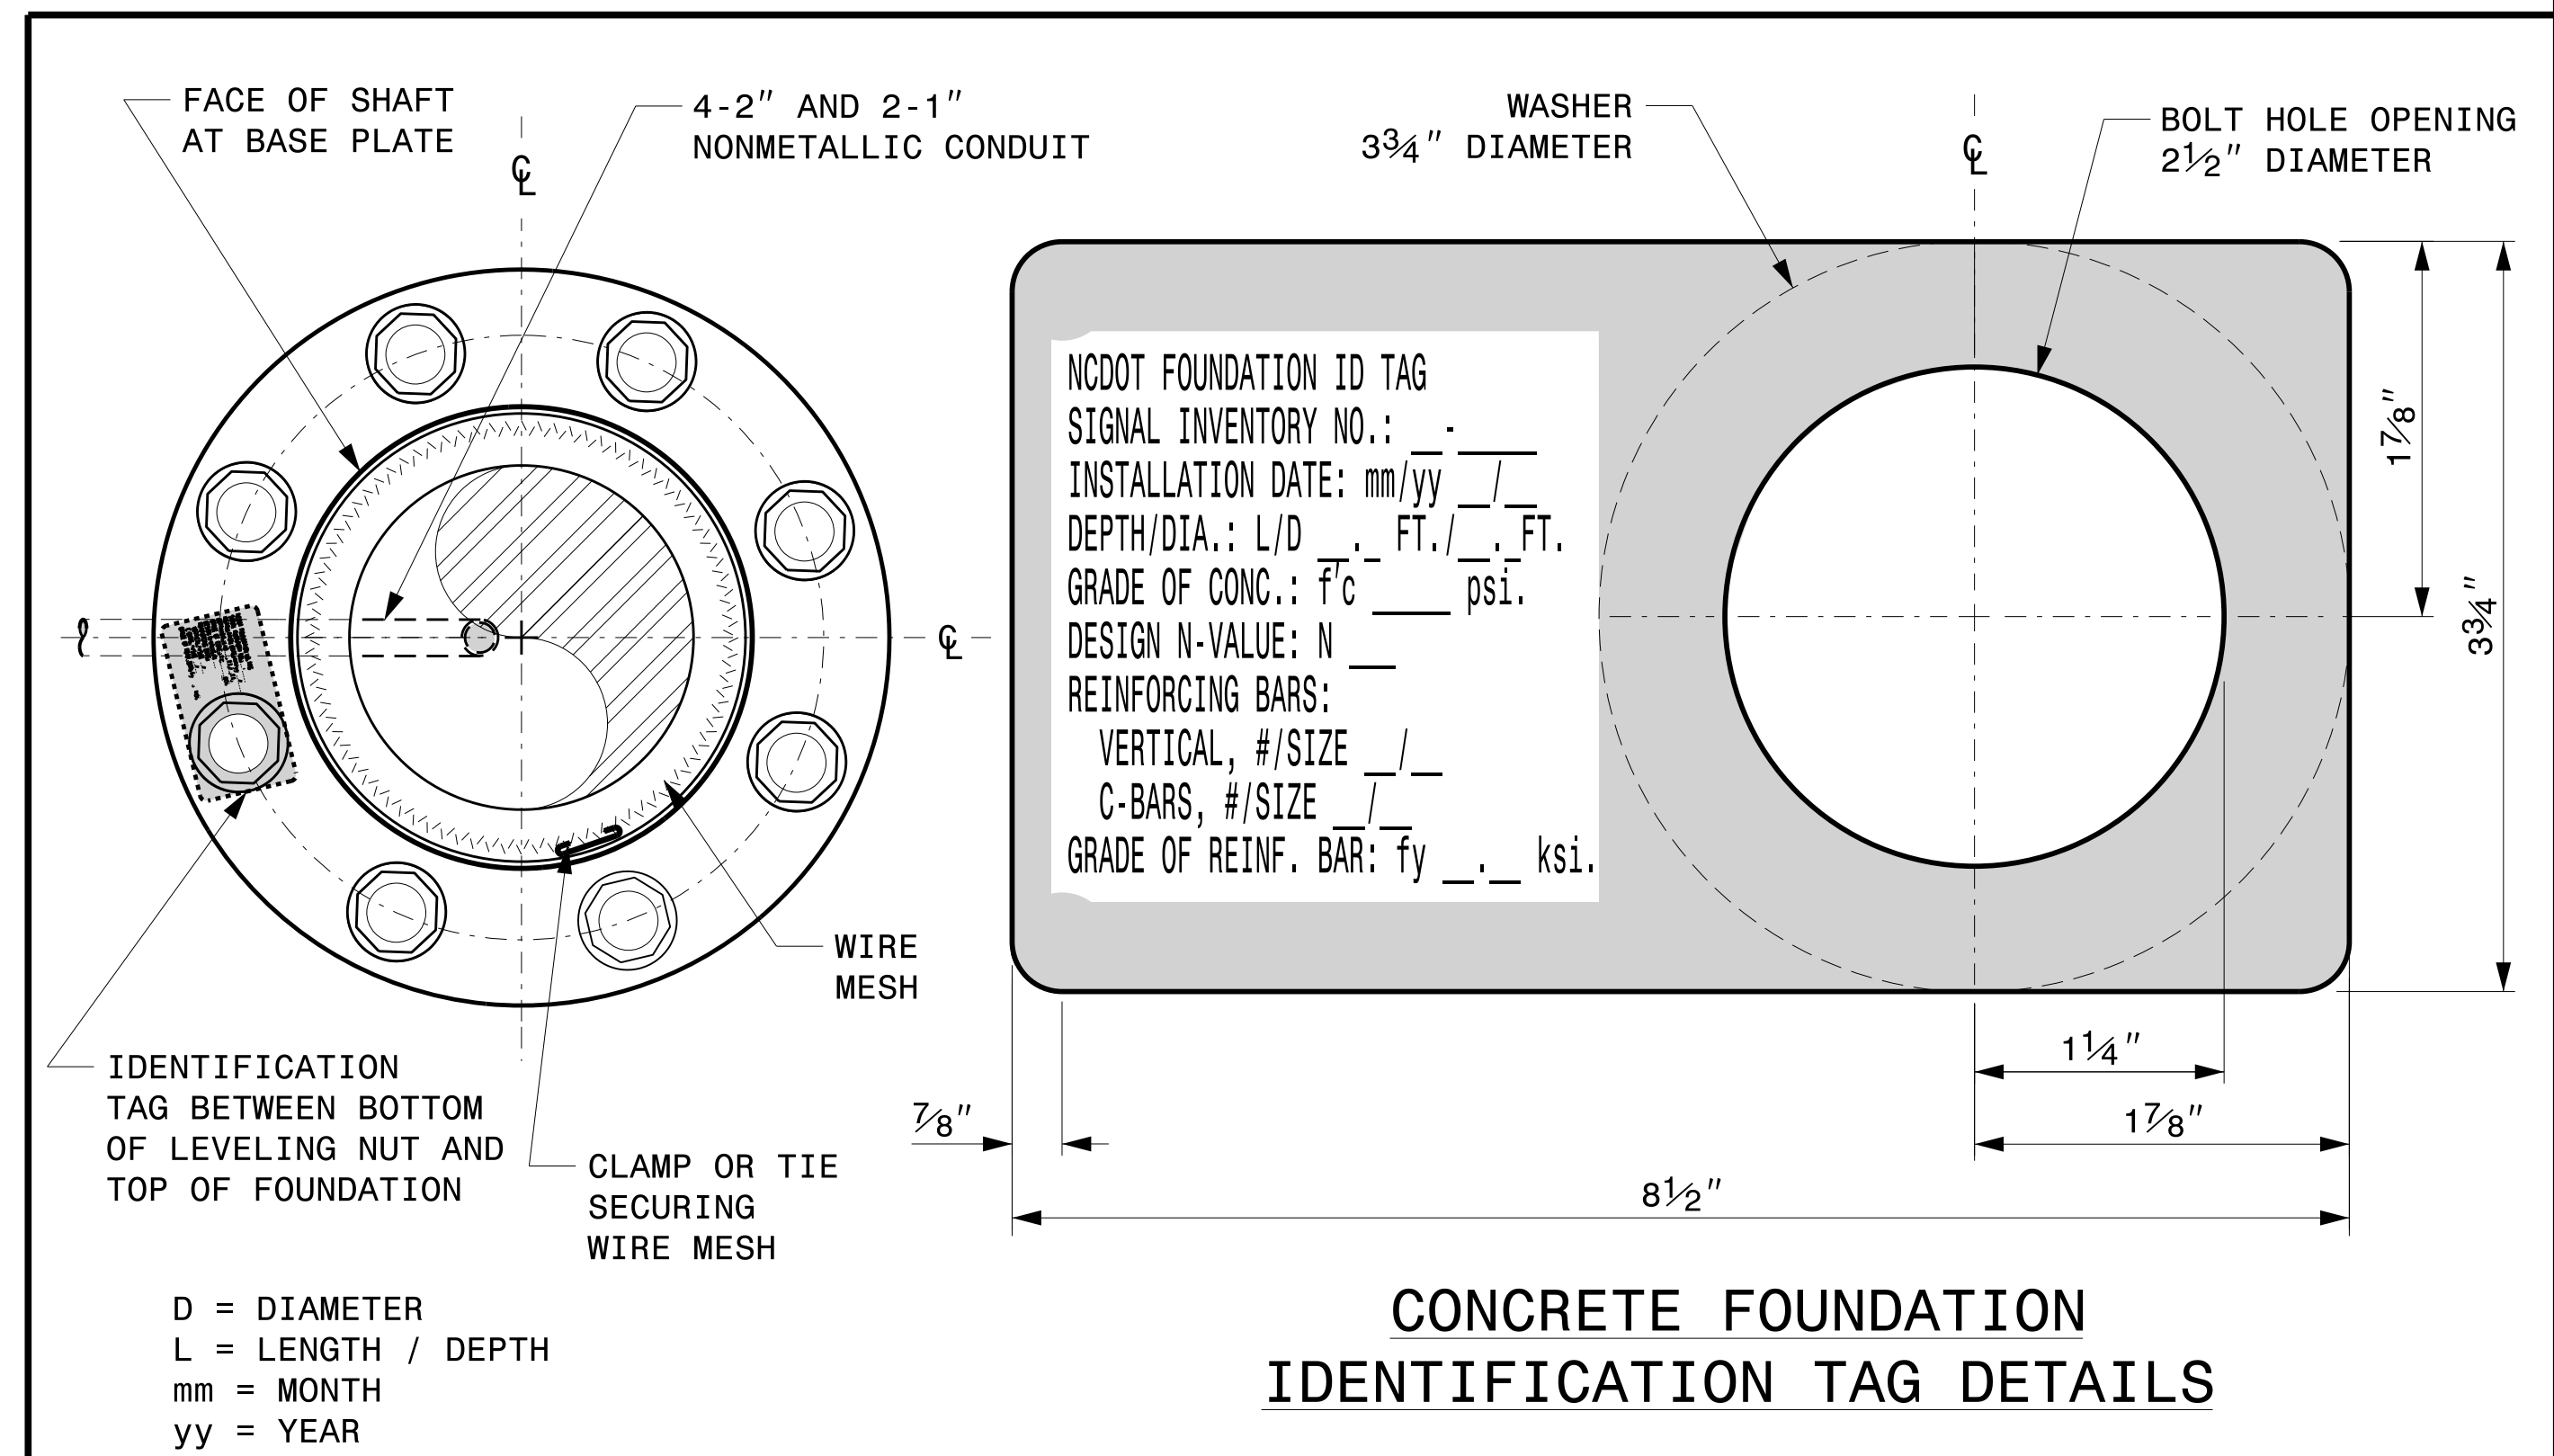

DETAIL-A

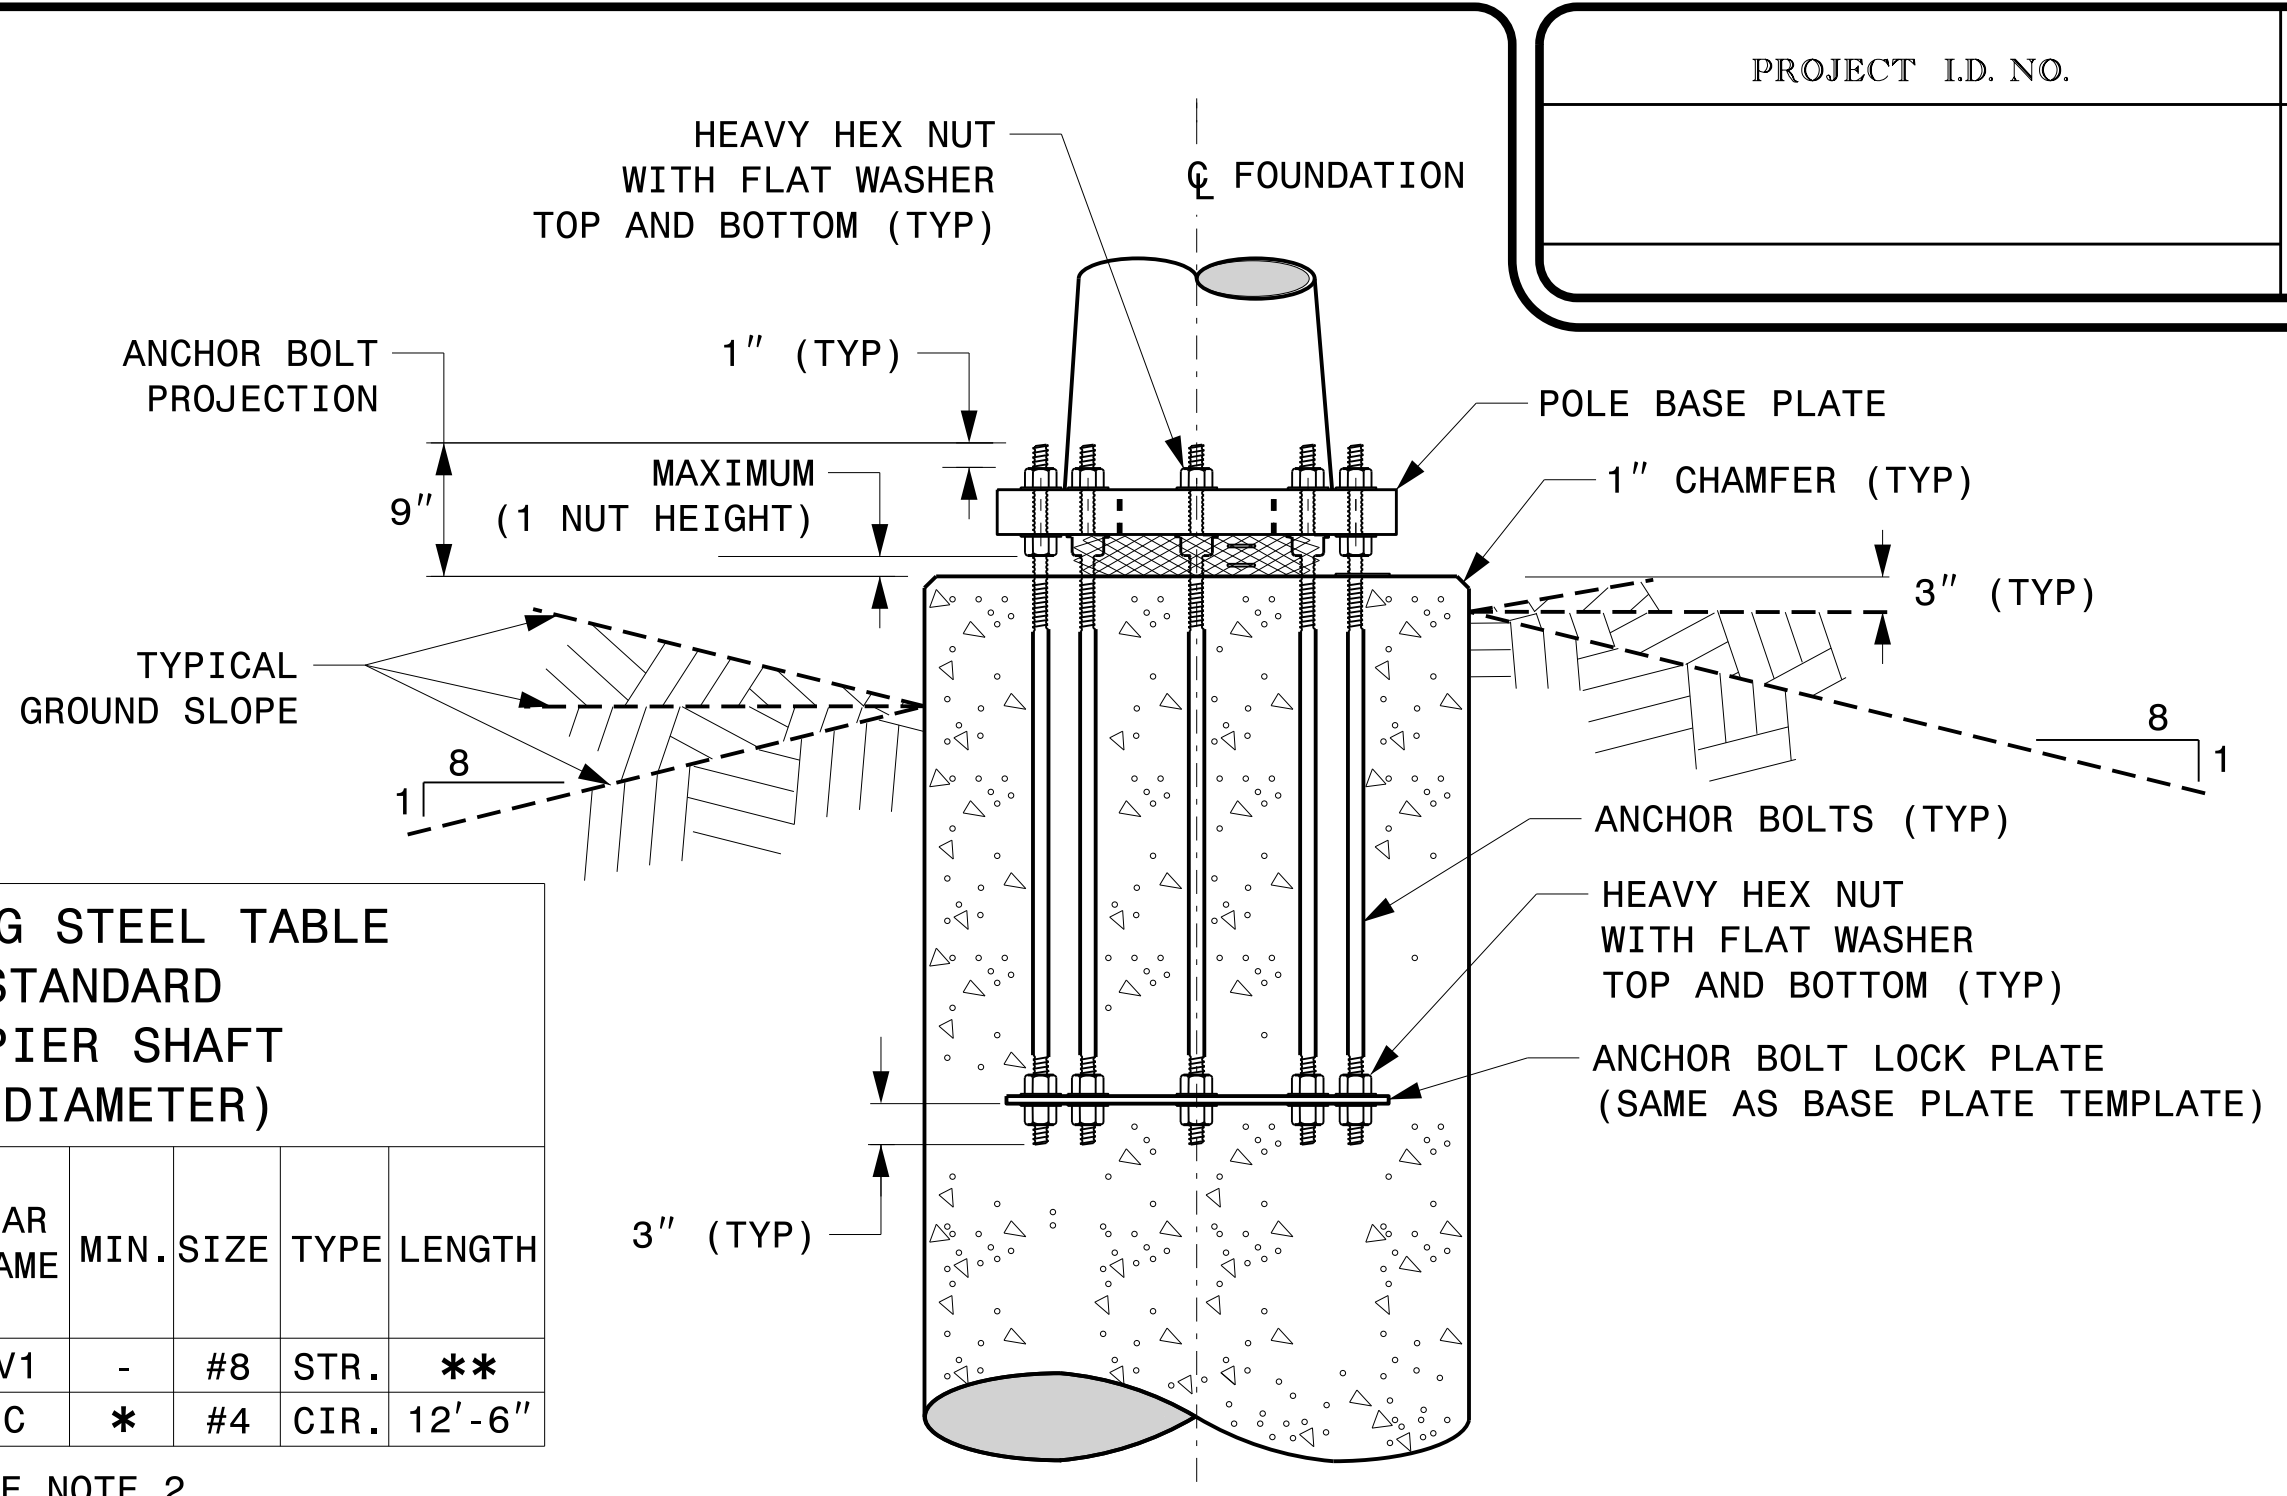

TYPICAL FOUNDATION ANCHOR BOLT DETAILS
(REINFORCING CAGE NOT SHOWN FOR CLARITY)

Prepared In the Offices of:

750 N.Greenfield Pkwy,Garner,NC 27529

SCALE
0 NA
NONE

Construction Details
For
Foundations

PLAN DATE: SEPTEMBER 2023 DESIGNED BY: K.C. DURIGON
PREPARED BY: K.C. DURIGON REVIEWED BY: D.C. SARKAR

REVISIONS
INIT. DATE

SEAL
NORTH CAROLINA
PROFESSIONAL ENGINEER
SEAL 036626
KEVIN C. DURIGON

DocuSigned by:
Kevin Durigon
4B23DC79B3784DA

09/23/2023
DATE

03-dgt-2023 19-46
S:\1\SS14115 Signal\Signal Design Section\Structures\Drawings\2024 Metal Pole Std Drawings for LRF\02024 Sig.M7 Std. Construction Details-Strain Poles.dgn
Kedur.fgm

SOIL CONDITION

STANDARD STRAIN POLES						STANDARD FOUNDATIONS 48" Diameter Drilled Pier Length (L) – Feet							Reinforcement			
Case No.	Pole Height (Ft.)	Base Plate BC (In.)	Reactions at the Pole Base			Clay				Sand			Longitudinal		Stirrups	
			Axial (kip)	Shear (kip)	Moment (ft–kip)	Medium N–Value 4–8	Stiff N–Value 9–15	Very Stiff N–Value 16–30	Hard N–Value > 30	Loose N–Value 4–10	Medium N–Value 11–30	Dense N–Value > 30	Bar Size (#)	Quantity (ea.)	Bar Size (#)	Spacing (in.)
S26L1	26	22	2	9	210	19.5	12.5	9	6.5	15.5	14.5	13	8	12	4	12
S26L2	26	23	2	10	240	19.5	12	9	6.5	15.5	14.5	13	8	12	4	12
S26L3	26	25	2	11	260	20.5	12	10	8	16	15	13	8	12	4	12
S30L1	30	22	2	9	230	19	11	9	7	15.5	14	12.5	8	12	4	12
S30L2	30	23	2	10	270	20	12	10	8	16	14.5	13	8	12	4	12
S30L3	30	25	2	11	290	21	12	10	8	17	15	13.5	8	12	4	12
S30H1	30	25	3	13	355	23	13	11	9	18	16.5	14.5	8	12	4	12
S30H2	30	29	3	15	405	25	14	11	9	19	17.5	15.5	8	14	4	12
S30H3	30	29	3	16	430	26	15	12	9	20	18	16	8	14	4	6
S35L1	35	22	3	8	260	19.5	12	10	8	15.5	14.5	13	8	12	4	12
S35L2	35	23	3	10	300	21	12	10	8	16.5	15	13.5	8	12	4	12
S35L3	35	25	3	10	320	21.5	13	10	8	17	15.5	14	8	12	4	12
S35H1	35	25	3	12	390	23.5	14	11	9	18	17	15	8	14	4	12
S35H2	35	29	4	14	460	26	15	12	9	20	18	16	8	14	4	6
S35H3	35	29	4	16	495	28.5	15	13.5	10	21.5	19	17	8	14	4	6

48" DIAMETER FOUNDATION CONCRETE VOLUME (CUBIC YARDS) = (0.465) x DRILLED PIER LENGTH

PROJECT I.D. NO.	SHEET NO.
	Sig.M8

GENERAL NOTES:


1. VALUES SHOWN IN THE "REACTIONS AT THE POLE BASE" COLUMN REPRESENT THE MINIMUM ACCEPTABLE CAPACITY ALLOWED FOR DESIGN USING A COMBINED FORCE RATIO (CFR) OF 1.00.
2. USE CHAIRS AND SPACERS TO MAINTAIN PROPER CLEARANCE.
3. FOR FOUNDATION, ALWAYS USE AIR-ENTRAINED CONCRETE MIX.

FOUNDATION SELECTION:

1. PERFORM A STANDARD PENETRATION TEST AT EACH PROPOSED FOUNDATION SITE TO DETERMINE "N" VALUE.
2. SELECT THE APPROPRIATE WIND ZONE FROM M1 DRAWING.
3. SELECT THE SOIL TYPE (CLAY OR SAND) THAT BEST DESCRIBES THE SOIL CHARACTERISTICS.
4. GET THE APPROPRIATE STANDARD POLE CASE NUMBER FROM THE PLANS OR FROM THE ENGINEER.
5. SELECT THE APPROPRIATE COLUMN UNDER "STANDARD FOUNDATIONS" BASED ON SOIL TYPE AND "N" VALUE. SELECT THE APPROPRIATE ROW BASED ON THE POLE LOAD CASE.
6. THE FOUNDATION DEPTH IS THE VALUE SHOWN IN THE "STANDARD FOUNDATIONS" CATEGORY WHERE THE COLUMN AND THE ROW INTERSECT.
7. USE CONSTRUCTION PROCEDURES AND DESIGN METHODS PRESCRIBED BY FHWA-NHI-10-016 MANUAL FOR DRILLED SHAFTS.

09-001-2023 19x48
S:\1\SSM1415 Signal\Signal Design Section\Structures\Drawings\2024 Metal Pole Str Drawing for LBF02024 Sig.M8 Str. Strain Pole Found.-Saturated Soil Condition.dgn
Kedur.fgm

Prepared In the Offices of:

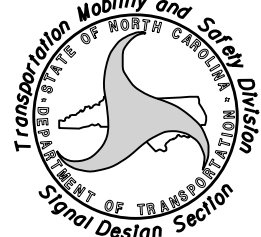

750 N.Greenfield Pkwy,Garner,NC 27529

SCALE

0 1"=10' NA

NONE

Standard Strain Pole Foundation for All Soil Conditions

PLAN DATE: SEPTEMBER 2023DESIGNED BY: K.C. DURIGON


PREPARED BY: K.C. DURIGONREVIEWED BY: D.C. SARKAR

REVISIONS

INIT.

DATE

SEAL

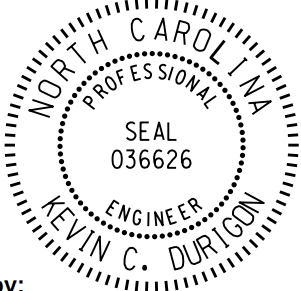

ENGINEER
KEVIN C. DURIGON

DocuSigned by:



4B23DC79B3784DA

 
09/21/2023

DATE

Standard Strain Pole Foundation – All Soil Conditions



CCTV CAMERA POLE
(NOT TO SCALE)

- | <p>Prepared In The Offices of:</p> <div style="text-align: center;">  <p>TRANSPORTATION MOBILITY AND SAFETY DIVISION
STATE OF NORTH CAROLINA
SEAL OF TRANSPORTATION
Sign Design Section</p> </div> <p>750 N. Greenfield Pkwy, Garner, NC 27529</p> | <h2 style="margin: 0;">Typical Fabrication Details</h2> <h3 style="margin: 0;">For</h3> <h2 style="margin: 0;">CCTV Poles</h2> | <p>SEAL</p> <div style="text-align: center;">  </div> | | | | | |
|---|--|--|---------------------------|---------------------------|------|---------------------------|---------------------------|
| <table style="width: 100%; border-collapse: collapse;"> <tr> <td style="width: 33%; border-bottom: 1px solid black;">PLAN DATE: SEPTEMBER 2023</td> <td style="width: 33%; border-bottom: 1px solid black;">DESIGNED BY: K.C. DURIGON</td> <td style="width: 33%;"></td> </tr> <tr> <td style="border-bottom: 1px solid black;">PREPARED BY: K.C. DURIGON</td> <td style="border-bottom: 1px solid black;">REVIEWED BY: C.F. ANDREWS</td> <td></td> </tr> </table> | | | PLAN DATE: SEPTEMBER 2023 | DESIGNED BY: K.C. DURIGON | | PREPARED BY: K.C. DURIGON | REVIEWED BY: C.F. ANDREWS | |
| PLAN DATE: SEPTEMBER 2023 | DESIGNED BY: K.C. DURIGON | | | | | | |
| PREPARED BY: K.C. DURIGON | REVIEWED BY: C.F. ANDREWS | | | | | | |
| <table style="width: 100%; border-collapse: collapse;"> <tr> <th style="width: 50%; text-align: center; border-bottom: 1px solid black;">REVISIONS</th> <th style="width: 10%; text-align: center; border-bottom: 1px solid black;">INIT.</th> <th style="width: 40%; text-align: center; border-bottom: 1px solid black;">DATE</th> </tr> <tr><td style="border-bottom: 1px solid black;"> </td><td style="border-bottom: 1px solid black;"> </td><td style="border-bottom: 1px solid black;"> </td></tr> <tr><td style="border-bottom: 1px solid black;"> </td><td style="border-bottom: 1px solid black;"> </td><td style="border-bottom: 1px solid black;"> </td></tr> <tr><td style="border-bottom: 1px solid black;"> </td><td style="border-bottom: 1px solid black;"> </td><td style="border-bottom: 1px solid black;"> </td></tr> <tr><td style="border-bottom: 1px solid black;"> </td><td style="border-bottom: 1px solid black;"> </td><td style="border-bottom: 1px solid black;"> </td></tr> <tr><td style="border-bottom: 1px solid black;"> </td><td style="border-bottom: 1px solid black;"> </td><td style="border-bottom: 1px solid black;"> </td></tr> <tr><td style="border-bottom: 1px solid black;"> </td><td style="border-bottom: 1px solid black;"> </td><td style="border-bottom: 1px solid black;"> </td></tr> <tr><td style="border-bottom: 1px solid black;"> </td><td style="border-bottom: 1px solid black;"> </td><td style="border-bottom: 1px solid black;"> </td></tr> <tr><td style="border-bottom: 1px solid black;"> </td><td style="border-bottom: 1px solid black;"> </td><td style="border-bottom: 1px solid black;"> </td></tr> <tr><td style="border-bottom: 1px solid black;"> </td><td style="border-bottom: 1px solid black;"> </td><td style="border-bottom: 1px solid black;"> </td></tr> </table> | | | REVISIONS | INIT. | DATE | | |
| REVISIONS | INIT. | DATE | | | | | |
| | | | | | | | |
| | | | | | | | |
| <div style="display: flex; justify-content: space-between; align-items: center;"> <div style="width: 45%;"> <p style="text-align: center;">SCALE</p> <div style="display: flex; align-items: center; justify-content: center;"> 0 <div style="width: 100px; height: 10px; background: linear-gradient(to right, black 50%, white 50%); border: 1px solid black; position: relative;"> <div style="position: absolute; right: 0; top: 0; bottom: 0; width: 5px; background: black;"></div> </div> NA </div> <p style="text-align: center; margin-top: 5px;">NONE</p> </div> <div style="width: 50%; text-align: right;"> <p>DocuSigned by:</p> <div style="border-bottom: 1px solid black; display: flex; align-items: center; justify-content: center;"> <div style="text-align: center;"> <p><i>Kevin Durigon</i></p> <p>SIGNATURE</p> </div> </div> <p>4R23DC79R3784DA</p> </div> </div> | | | | | | | |
| | | <p>09/21/2023</p> <p>DATE</p> | | | | | |

6/8/2026 9:08:06 AM susan.pennington ***I:\Inlay-Horn.com\CL_Chill\CHILL_PRJ\011036264 - I-5715\Signal\456 - Cable Routing\ConstructionNotes.dgn

- 1

INSTALL COAX CABLE
- 2

INSTALL ETHERNET CABLE
- 3

EXISTING ETHERNET (OR COAX) CABLE
- 4

INSTALL SMFO CABLE
- 5

EXISTING SMFO CABLE
- 6

INSTALL FIBER OPTIC DROP CABLE
- 7

INSTALL TRACER WIRE
- 8

TRENCH
- 9

INSTALL PVC CONDUIT
- 10

INSTALL RIGID, GALVANIZED STEEL CONDUIT
- 11

INSTALL RIGID, GALVANIZED STEEL RISER WITH WEATHERHEAD
- 12

INSTALL RIGID, GALVANIZED STEEL RISER WITH FIBER OPTIC CABLE SEAL
- 13

INSTALL OUTER-DUCT POLYETHYLENE CONDUIT
- 14

INSTALL POLYETHYLENE CONDUIT
- 15

DIRECTIONAL DRILL CONDUIT
- 16

BORE AND JACK CONDUIT
- 17

INSTALL CABLE(S) IN EXISTING CONDUIT
- 18

INSTALL CABLE(S) IN NEW CONDUIT
- 19

INSTALL CABLE(S) IN EXISTING RISER
- 20

INSTALL CABLE(S) IN NEW RISER
- 21

INSTALL CABLE(S) IN EXISTING CONDUIT STUB-OUTS
- 22

INSTALL NEW CONDUIT INTO EXISTING CABINET BASE (USE EXISTING CONDUIT STUB-OUTS WHEN AVAILABLE)
- 23

INSTALL NEW RISER INTO EXISTING CABINET BASE (USE EXISTING CONDUIT STUB-OUTS WHEN AVAILABLE)
- 24

INSTALL NEW CONDUIT INTO EXISTING POLE MOUNTED CABINET
- 25

INSTALL NEW RISER INTO EXISTING POLE MOUNTED CABINET
- 26

INSTALL NEW ETHERNET EDGE SWITCH
- 27

INSTALL NEW FIBER OPTIC TRANSCEIVER
- 28

INSTALL INTERCONNECT CENTER, PATCH PANEL, JUMPERS AND FUSION SPLICE CABLE IN CABINET
- 29

INSTALL UNDERGROUND SPLICE ENCLOSURE
- 30

INSTALL AERIAL SPLICE ENCLOSURE
- 31

MODIFY EXISTING INTERCONNECT CENTER /SPLICE ENCLOSURE
- 32

INSTALL POLE MOUNTED SPLICE CABINET
- 33

INSTALL BASE MOUNTED SPLICE CABINET

- 34

INSTALL CABINET FOUNDATION
- 35

INSTALL CCTV CAMERA POLE MOUNTED CABINET
- 36

INSTALL CCTV CAMERA ASSEMBLY
- 37

INSTALL CCTV CAMERA WOOD POLE
- 38

INSTALL CCTV CAMERA METAL POLE AND FOUNDATION
- 39

INSTALL JUNCTION BOX
- 40A

INSTALL OVERSIZED JUNCTION BOX
- 40B

INSTALL SPECIAL OVERSIZED JUNCTION BOX (36" x 24" x 24")
- 41

REMOVE EXISTING JUNCTION BOX
- 42

INSTALL WOOD POLE
- 43

REMOVE EXISTING WOOD POLE
- 44

INSTALL AERIAL GUY ASSEMBLY
- 45

INSTALL STANDARD GUY ASSEMBLY
- 46

INSTALL SIDEWALK GUY ASSEMBLY
- 47

INSTALL MESSENGER CABLE
- 48A

REMOVE EXISTING COMMUNICATIONS AND MESSENGER CABLE
- 48B

REMOVE EXISTING COMMUNICATIONS CABLE
- 49

BACK PULL EXISTING COMMUNICATIONS CABLE
- 50

INSTALL CELL MODEM AND ANTENNA
- 51

INSTALL CABLE STORAGE RACKS (SNOW SHOES) AND STORE 100 FEET OF CABLE
- 52A

INSTALL DELINEATOR MARKER
- 52B

INSTALL JUNCTION BOX MARKER
- 53A

STORE 20 FEET OF COMMUNICATIONS CABLE
- 53B

STORE 50 FEET OF EACH COMMUNICATIONS CABLE
- 54

LASH CABLE(S) TO EXISTING COMMUNICATIONS CABLE
- 55

LASH CABLE(S) TO EXISTING MESSENGER CABLE
- 56

LASH CABLE(S) TO NEW MESSENGER CABLE
- 57

MODIFY EXISTING ELECTRICAL SERVICE
- 58

INSTALL NEW ELECTRICAL SERVICE
- 59

INSTALL NEW EQUIPMENT CABINET DISCONNECT
- 60

BOND TRACER WIRE TO EQUIPMENT GROUND BUS
DO NOT BOND TRACER WIRE TO EQUIPMENT GROUND BUS
- 61

BOND RISER AND MESSENGER CABLE TO POLE GROUND
- 62

BOND RISER TO POLE GROUND
- 63

BOND MESSENGER CABLE TO POLE GROUND
- 64

INSTALL HEAT SHRINK TUBING RETROFIT KIT
- 65

INSTALL MOLDABLE DUCT SEAL
- 66

SLACK SPAN
- 67

ATTACHMENT POINT:

XX"SS
YYY

DISTANCE ABOVE (IN)/ATTACHMENT POINT
REFERENCE POINT

YYY
XX"SS

REFERENCE POINT
DISTANCE BELOW (IN)/ATTACHMENT POINT

"SS" REFERENCE LOCATION

FS = FRONT SIDE OF POLE
BS = BACK SIDE OF POLE

FO

NEW FIBER OPTIC COMMUNICATIONS CABLE

EXI

EXISTING COMMUNICATIONS CABLE

REM

EXISTING COMMUNICATIONS CABLE TO BE REMOVED

NEW AERIAL GUY ASSEMBLY

NEW CONDUIT

EXISTING CONDUIT

DD

NEW DIRECTIONAL DRILLED CONDUIT

NEW

OVERSIZED JUNCTION BOX

WOOD POLE

S

AERIAL SPLICE ENCLOSURE

S

UNDERGROUND SPLICE ENCLOSURE

METAL POLE

CCTV ASSEMBLY

STANDARD GUY ASSEMBLY

SIDEWALK GUY ASSEMBLY

CABLE STORAGE RACKS (SNOW SHOES)

SIGNAL EQUIPMENT CABINET

G

GATEWAY RADIO LOCATION

S

SPLICE CABINET

FLAT PANEL ANTENNA (SINGLE)

YAGI ANTENNA (DOUBLE) FOR REPEATER OPERATION

YAGI ANTENNA (SINGLE)

OMNI ANTENNA

SP

SIGNAL POLE

XX-XXXX

SIGNAL INVENTORY NUMBER

EXISTING

OVERSIZED JUNCTION BOX

WOOD POLE

S

AERIAL SPLICE ENCLOSURE

S

UNDERGROUND SPLICE ENCLOSURE

METAL POLE

CCTV ASSEMBLY

STANDARD GUY ASSEMBLY

SIDEWALK GUY ASSEMBLY

CABLE STORAGE RACKS (SNOW SHOES)

SIGNAL EQUIPMENT CABINET

G

GATEWAY RADIO LOCATION

S

SPLICE CABINET

FLAT PANEL ANTENNA (SINGLE)

YAGI ANTENNA (DOUBLE) FOR REPEATER OPERATION

YAGI ANTENNA (SINGLE)

OMNI ANTENNA

SP

SIGNAL POLE

XX-XXXX

SIGNAL INVENTORY NUMBER

CONSTRUCTION NOTE SYMBOLOGY KEY

XX

INDICATES NUMBER OF CABLES, LOOPS, ETC.

XX

INDICATES NUMBER OF FIBERS PER CABLE,
TWISTED PAIRS PER CABLE, ETC.

XX

INDICATES NUMBER OF RISER(S)/CONDUIT(S)

XX

INDICATES DIAMETER OF RISER(S)/CONDUIT(S) (INCH)

NUMBER OF CABLE(S)

NUMBER OF FIBERS/TWISTED PAIRS

NEW/EXISTING CABLE

REMOVE/MODIFY CABLE

CONDUIT/RISER

NUMBER OF RISER(S)/CONDUIT(S)

DIAMETER OF RISER(S)/CONDUIT(S) (INCH)

PLANS PREPARED IN THE OFFICE OF:
Kimley»Horn
Intelligent Transportation Systems Section
750 N. Greenfield Pkwy, Garner, NC 27529
NC License #F-0102
421 Fayetteville Street, Suite 600
Raleigh, NC 27601
(919) 677-2000

Prepared For:

Transportation Mobility and Safety Division
DEPARTMENT OF TRANSPORTATION
STATE OF NORTH CAROLINA

PLAN DATE: February 2026

REVIEWED BY: MC Burke

PREPARED BY: SP Pennington

REVIEWED BY:

SCALE

0

N.T.S.

D10-43_Huntersville

Construction Notes

Division 10 Mecklenburg County Huntersville

REVISIONS

INIT.

DATE

DOCUMENT NOT CONSIDERED
FINAL UNLESS ALL
SIGNATURES COMPLETED

SEAL

NORTH CAROLINA
PROFESSIONAL
SEAL
058683
ENGINEER
WOLLY C. BURKE


DocuSigned by

Molly Burke

6/9/2026

SIG. INVENTORY NO.

PROJECT REFERENCE NO.	SHEET NO.
I-5715	SCP-02

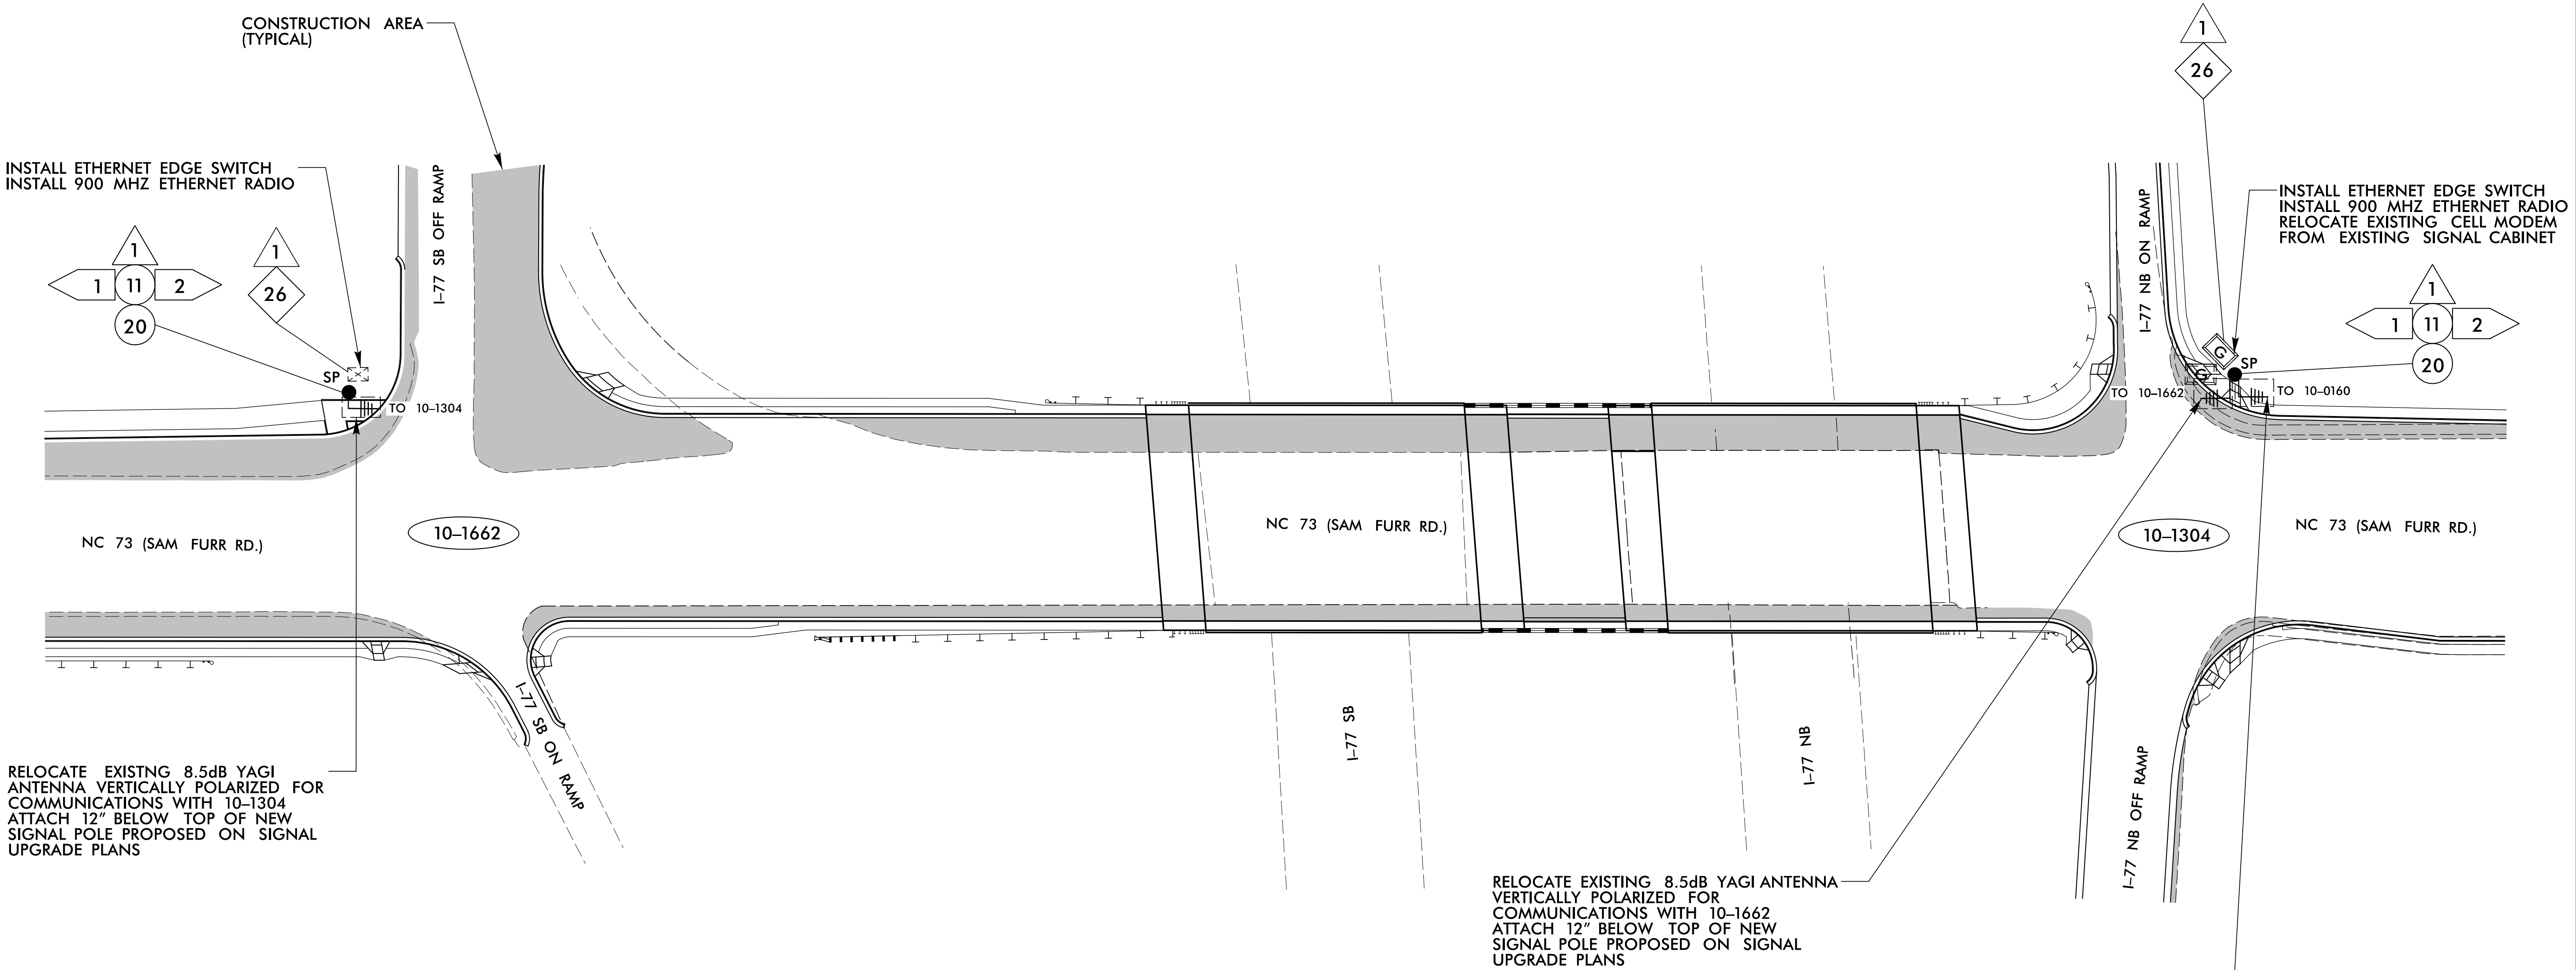


- NOTES FOR WIRELESS COMMUNICATIONS:
- FIVE (5) DAYS PRIOR TO BEGINNING WORK ON THE SIGNAL SYSTEM, CONTACT THE DIVISION 10 TRAFFIC ENGINEER AT 704-983-440. NOTIFY THE DEPUTY DIVISION TRAFFIC ENGINEER AFTER ALL WORK IS PERFORMED TO ENSURE THAT ALL WIRELESS CIRCUITS ARE FUNCTIONING PROPERLY. WORK IS NOT COMPLETE UNTIL ALL SIGNALS ARE COMMUNICATING WITH THE CENTRAL SYSTEM.
 - INSTALL COAXIAL CABLE:
 - ON WOOD POLES, REQUIRING A NEW RIGID GALVANIZED STEEL RISER, INSTALL A 2" RISER WITH WEATHERHEAD AND ROUTE THE COAXIAL CABLE TO THE ANTENNA.
 - ON METAL POLES WITH MAST ARMS, RUN COAXIAL CABLE UP THROUGH THE POLE AND OUT THE MAST ARM; FIELD DRILL A 1/2" HOLE UP THROUGH THE BOTTOM OF MAST ARM FOR INSTALLATION OF THE COAXIAL CABLE TO THE ANTENNA.
 - ON METAL STRAIN POLES, RUN COAXIAL CABLE UP THROUGH THE POLE AND OUT THE WEATHERHEAD AND ROUTE THE COAXIAL CABLE TO THE ANTENNA.
 - BETWEEN THE POINT OF EXITING THE RISER, METAL POLE OR MAST ARM AND THE ANTENNA, SECURE THE COAXIAL CABLE TO THE STRUCTURE USING 3/4" STAINLESS STEEL STRAPS EVERY 12".
 - IF AN EXISTING 2" SPARE RIGID GALVANIZED STEEL RISER IS AVAILABLE, INSTALL THE COAXIAL CABLE IN THE SPARE RISER WITH 2" WEATHERHEAD.
 - INSTALL WIRELESS ANTENNA ON POLE WITH RF WARNING SIGN.
(NOTE: RF WARNING SIGN NOT REQUIRED WHEN ANTENNA IS INSTALLED ON AN NCDOT-OWNED POLE.)
 - INSTALL WIRELESS RADIO WITH EXTERIOR DISCONNECT SWITCH LOCATED ON CABINET.
(NOTE: RF ANTENNA DISCONNECT SWITCH AND DECAL ARE NOT REQUIRED WHEN THE ANTENNA IS INSTALLED ON AN NCDOT-OWNED POLE.)
 - MAINTAIN PROPER CLEARANCE FROM ALL UTILITIES PER THE NATIONAL ELECTRICAL SAFETY CODE.
 - REFERENCE SPREAD SPECTRUM RADIO ROADWAY STANDARD DRAWINGS 1736.01.
 - CELL MODEMS TO BE SUPPLIED BY THE DEPARTMENT. CONTACT THE DIVISION TRAFFIC ENGINEER AT 704-983-440. , TO REQUEST THE CELL MODEM. ALLOW 8 WEEKS LEAD TIME BEFORE ANTICIPATED DEPLOYMENT.

RELOCATE EXISTING 8.5dB YAGI ANTENNA VERTICALLY POLARIZED FOR COMMUNICATIONS WITH 10-1662 ATTACH 12" BELOW TOP OF NEW SIGNAL POLE PROPOSED ON SIGNAL UPGRADE PLANS

RELOCATE EXISTING 8.5dB YAGI ANTENNA VERTICALLY POLARIZED FOR COMMUNICATIONS WITH 10-0610 ATTACH 18" BELOW TOP OF NEW SIGNAL POLE ON SIGNAL UPGRADE PLANS

Temporary Wireless - TMP Ph 2-4b


PLANS PREPARED IN THE OFFICE OF:
Kimley»Horn
Intelligent Transportation Systems Section
750 N. Greenfield Pkwy, Garner, NC 27529
NC License #F-0102
421 Fayetteville Street, Suite 600
Raleigh, NC 27601
(919) 677-2000

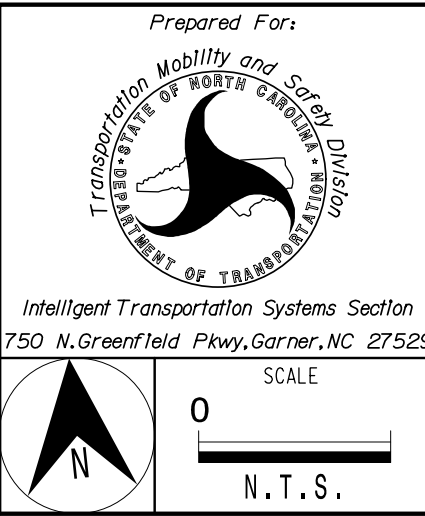

D10-43_Huntersville		
Spread Spectrum Wireless Radio Interconnect		
Division 10 Mecklenburg County Huntersville		
PLAN DATE: February 2026		REVIEWED BY: MC Burke
PREPARED BY: SP Pennington		REVIEWED BY:
REVISIONS		INIT. DATE

DOCUMENT NOT CONSIDERED FINAL UNLESS ALL SIGNATURES COMPLETED	
SEAL	SEAL
NORTH CAROLINA PROFESSIONAL ENGINEER	NORTH CAROLINA PROFESSIONAL ENGINEER
WOLLY C. BURKE	WOLLY C. BURKE
SEAL 058683	SEAL 058683
DocuSigned by	DocuSigned by
Molly Burke	Molly Burke
SIGNATURE	SIGNATURE
DATE	DATE
6/9/2026	6/9/2026
SIG. INVENTORY NO.	SIG. INVENTORY NO.

PROJECT REFERENCE NO.	SHEET NO.
I-5715	SCP-03

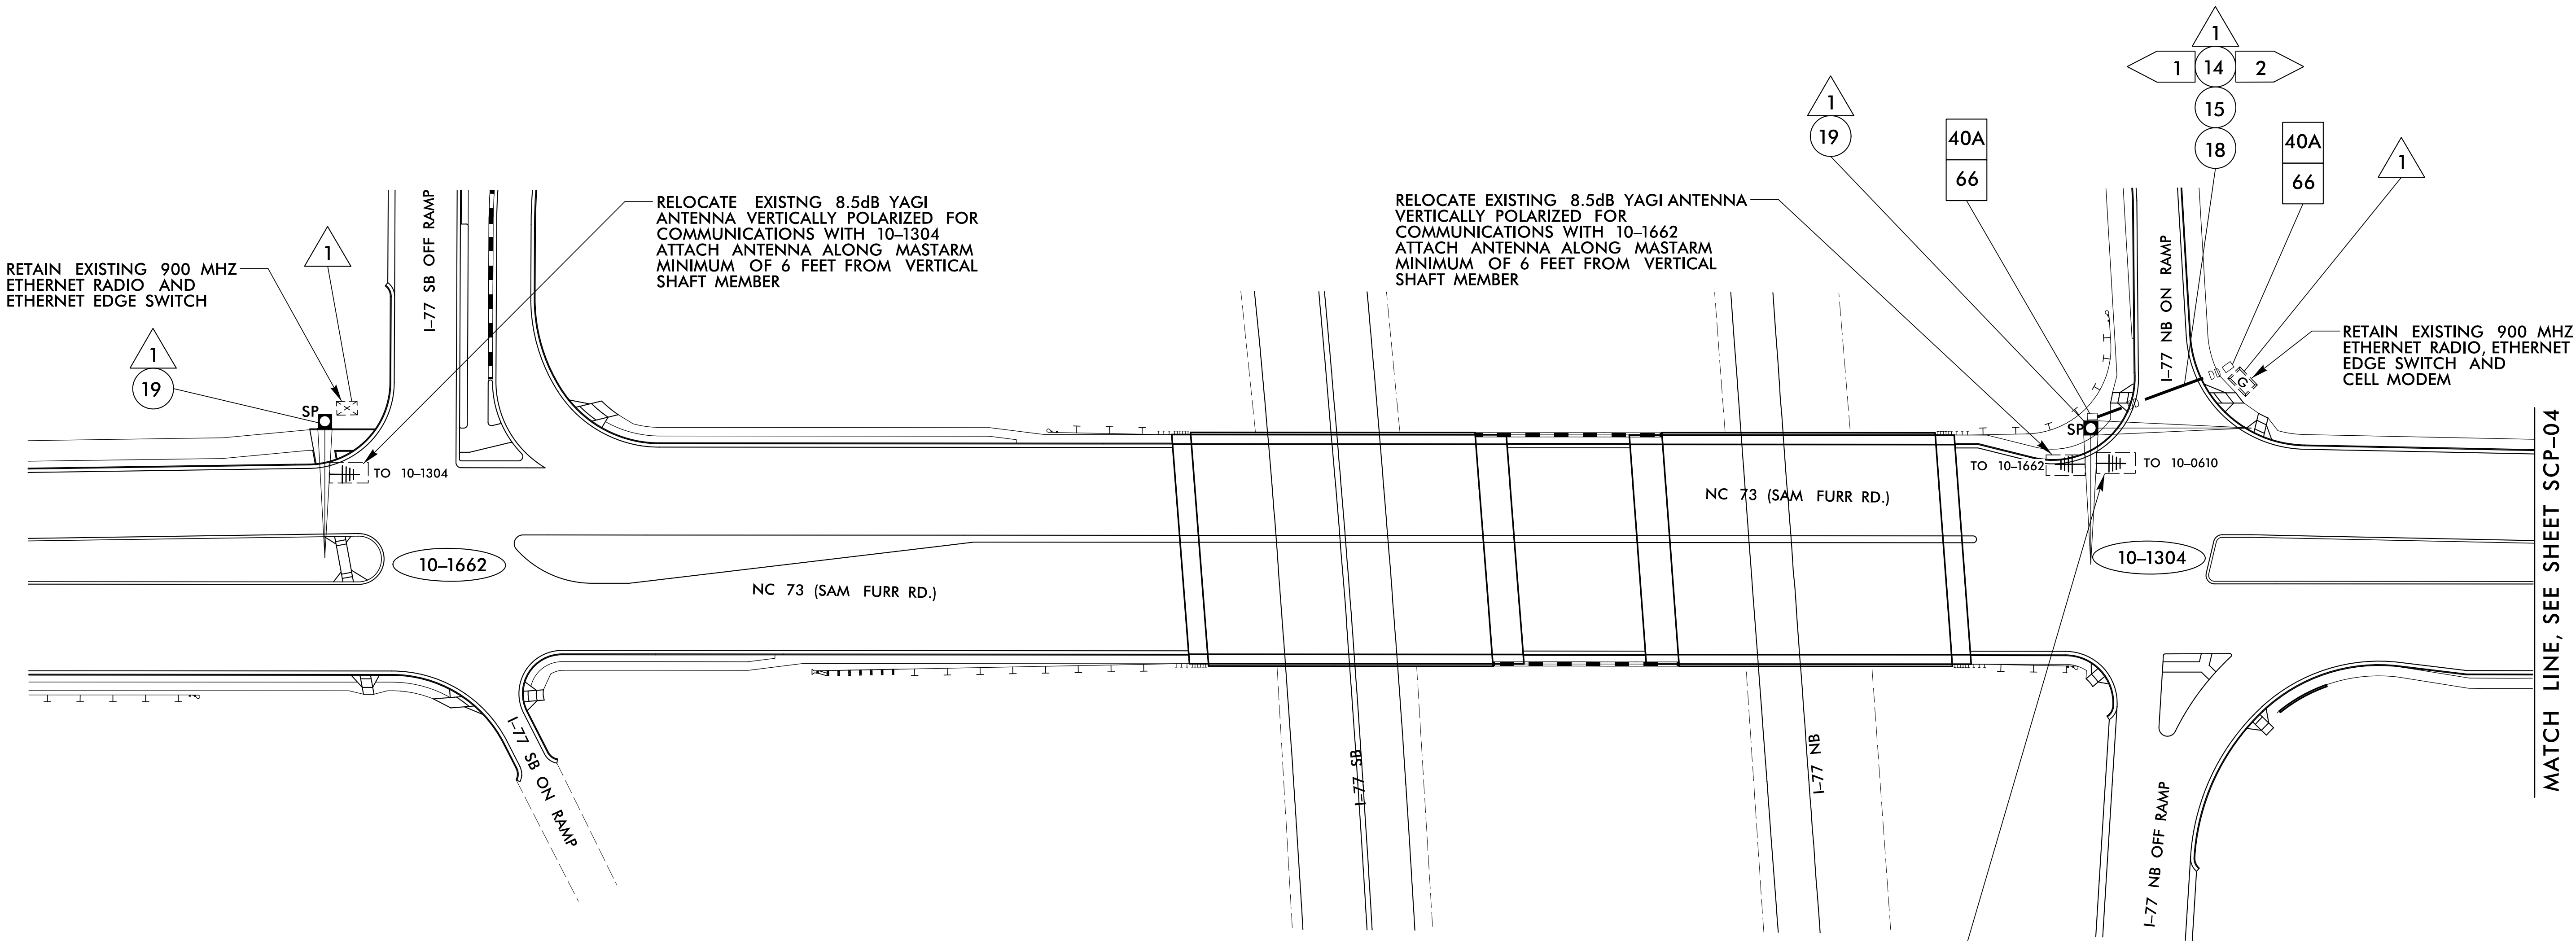


NOTES FOR WIRELESS COMMUNICATIONS:

1. FIVE (5) DAYS PRIOR TO BEGINNING WORK ON THE SIGNAL SYSTEM, CONTACT THE DIVISION 10 TRAFFIC ENGINEER AT 704-983-440. NOTIFY THE DEPUTY DIVISION TRAFFIC ENGINEER AFTER ALL WORK IS PERFORMED TO ENSURE THAT ALL WIRELESS CIRCUITS ARE FUNCTIONING PROPERLY. WORK IS NOT COMPLETE UNTIL ALL SIGNALS ARE COMMUNICATING WITH THE CENTRAL SYSTEM.
2. INSTALL COAXIAL CABLE:
 - A. ON WOOD POLES, REQUIRING A NEW RIGID GALVANIZED STEEL RISER, INSTALL A 2" RISER WITH WEATHERHEAD AND ROUTE THE COAXIAL CABLE TO THE ANTENNA.
 - B. ON METAL POLES WITH MAST ARMS, RUN COAXIAL CABLE UP THROUGH THE POLE AND OUT THE MAST ARM; FIELD DRILL A 1/2" HOLE UP THROUGH THE BOTTOM OF MAST ARM FOR INSTALLATION OF THE COAXIAL CABLE TO THE ANTENNA.
 - C. ON METAL STRAIN POLES, RUN COAXIAL CABLE UP THROUGH THE POLE AND OUT THE WEATHERHEAD AND ROUTE THE COAXIAL CABLE TO THE ANTENNA.
 - D. BETWEEN THE POINT OF EXITING THE RISER, METAL POLE OR MAST ARM AND THE ANTENNA, SECURE THE COAXIAL CABLE TO THE STRUCTURE USING 3/4" STAINLESS STEEL STRAPS EVERY 12".
3. IF AN EXISTING 2" SPARE RIGID GALVANIZED STEEL RISER IS AVAILABLE, INSTALL THE COAXIAL CABLE IN THE SPARE RISER WITH 2" WEATHERHEAD.
4. INSTALL WIRELESS ANTENNA ON POLE WITH RF WARNING SIGN.
(NOTE: RF WARNING SIGN NOT REQUIRED WHEN ANTENNA IS INSTALLED ON AN NCDOT-OWNED POLE.)
5. INSTALL WIRELESS RADIO WITH EXTERIOR DISCONNECT SWITCH LOCATED ON CABINET.
(NOTE: RF ANTENNA DISCONNECT SWITCH AND DECAL ARE NOT REQUIRED WHEN THE ANTENNA IS INSTALLED ON AN NCDOT-OWNED POLE.)
6. MAINTAIN PROPER CLEARANCE FROM ALL UTILITIES PER THE NATIONAL ELECTRICAL SAFETY CODE.
7. REFERENCE SPREAD SPECTRUM RADIO ROADWAY STANDARD DRAWINGS 1736.01.
8. CELL MODEMS TO BE SUPPLIED BY THE DEPARTMENT. CONTACT THE DIVISION TRAFFIC ENGINEER AT 704-983-440, TO REQUEST THE CELL MODEM. ALLOW 8 WEEKS LEAD TIME BEFORE ANTICIPATED DEPLOYMENT.

PLANS PREPARED IN THE OFFICE OF:
Kimley»Horn
Intelligent Transportation Systems Section
750 N. Greenfield Pkwy, Garner, NC 27529
NC License #F-0102
421 Fayetteville Street, Suite 600
Raleigh, NC 27601
(919) 677-2000


Final Phase

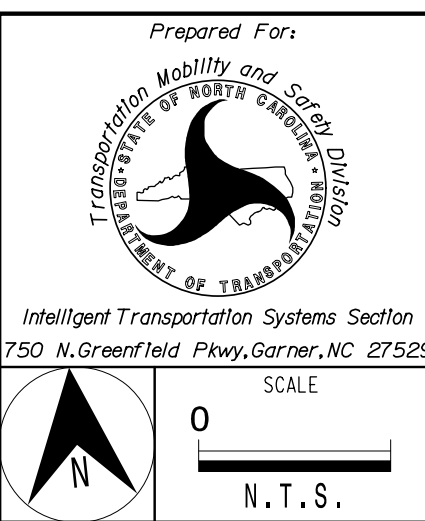

D10-43_Huntersville	
Spread Spectrum Wireless Radio Interconnect	
Division 10	Mecklenburg County Huntersville
PLAN DATE: February 2026	REVIEWED BY: MC Burke
PREPARED BY: SP Pennington	REVIEWED BY:
REVISIONS	INIT. DATE

DOCUMENT NOT CONSIDERED FINAL UNLESS ALL SIGNATURES COMPLETED
SEAL NORTH CAROLINA PROFESSIONAL ENGINEER SEAL 058883 WOLLY C. BURKE
DocuSigned by Molly Burke 6/9/2026 SIGNATURE DATE SIC. INVENTORY NO.

PROJECT REFERENCE NO.	SHEET NO.
I-5715	SCP-04



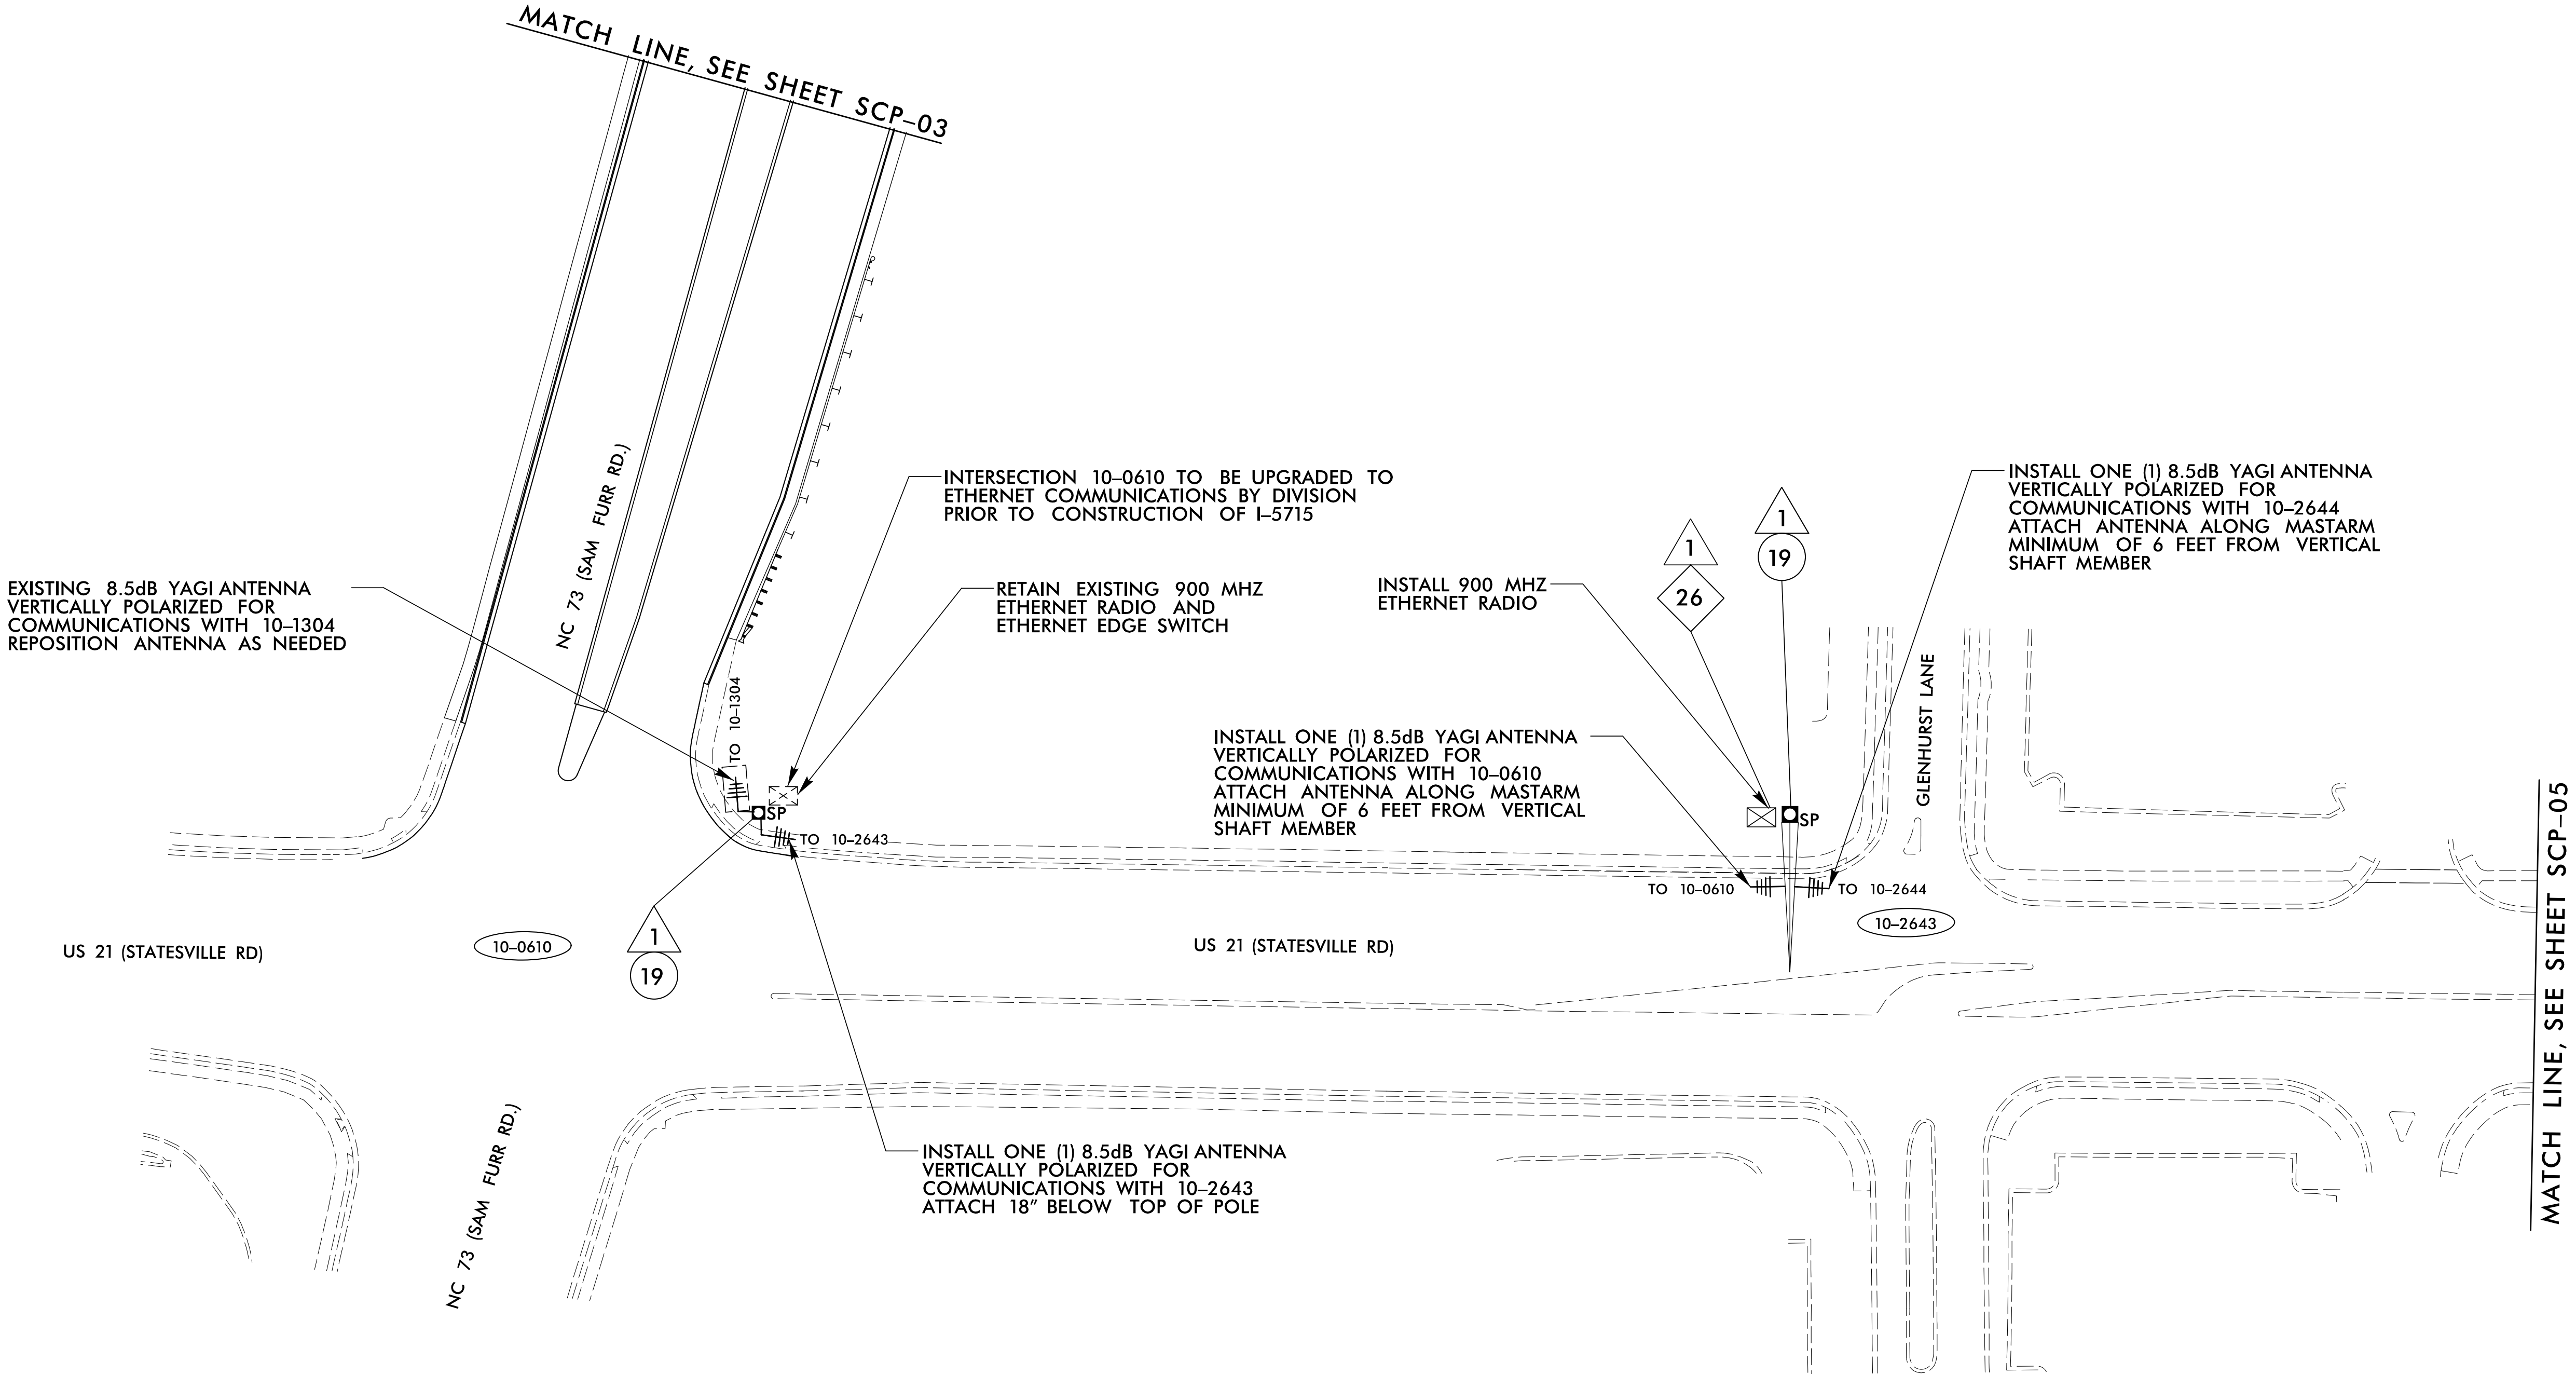


NOTES FOR WIRELESS COMMUNICATIONS:


1. FIVE (5) DAYS PRIOR TO BEGINNING WORK ON THE SIGNAL SYSTEM, CONTACT THE DIVISION 10 TRAFFIC ENGINEER AT 704-983-440. NOTIFY THE DEPUTY DIVISION TRAFFIC ENGINEER AFTER ALL WORK IS PERFORMED TO ENSURE THAT ALL WIRELESS CIRCUITS ARE FUNCTIONING PROPERLY. WORK IS NOT COMPLETE UNTIL ALL SIGNALS ARE COMMUNICATING WITH THE CENTRAL SYSTEM.
2. INSTALL COAXIAL CABLE:
 - A. ON WOOD POLES, REQUIRING A NEW RIGID GALVANIZED STEEL RISER, INSTALL A 2" RISER WITH WEATHERHEAD AND ROUTE THE COAXIAL CABLE TO THE ANTENNA.
 - B. ON METAL POLES WITH MAST ARMS, RUN COAXIAL CABLE UP THROUGH THE POLE AND OUT THE MAST ARM; FIELD DRILL A 1/2" HOLE UP THROUGH THE BOTTOM OF MAST ARM FOR INSTALLATION OF THE COAXIAL CABLE TO THE ANTENNA.
 - C. ON METAL STRAIN POLES, RUN COAXIAL CABLE UP THROUGH THE POLE AND OUT THE WEATHERHEAD AND ROUTE THE COAXIAL CABLE TO THE ANTENNA.
 - D. BETWEEN THE POINT OF EXITING THE RISER, METAL POLE OR MAST ARM AND THE ANTENNA, SECURE THE COAXIAL CABLE TO THE STRUCTURE USING 3/4" STAINLESS STEEL STRAPS EVERY 12".
3. IF AN EXISTING 2" SPARE RIGID GALVANIZED STEEL RISER IS AVAILABLE, INSTALL THE COAXIAL CABLE IN THE SPARE RISER WITH 2" WEATHERHEAD.
4. INSTALL WIRELESS ANTENNA ON POLE WITH RF WARNING SIGN.
(NOTE: RF WARNING SIGN NOT REQUIRED WHEN ANTENNA IS INSTALLED ON AN NCDOT-OWNED POLE.)
5. INSTALL WIRELESS RADIO WITH EXTERIOR DISCONNECT SWITCH LOCATED ON CABINET.
(NOTE: RF ANTENNA DISCONNECT SWITCH AND DECAL ARE NOT REQUIRED WHEN THE ANTENNA IS INSTALLED ON AN NCDOT-OWNED POLE.)
6. MAINTAIN PROPER CLEARANCE FROM ALL UTILITIES PER THE NATIONAL ELECTRICAL SAFETY CODE.
7. REFERENCE SPREAD SPECTRUM RADIO ROADWAY STANDARD DRAWINGS 1736.01.
8. CELL MODEMS TO BE SUPPLIED BY THE DEPARTMENT. CONTACT THE DIVISION TRAFFIC ENGINEER AT 704-983-440. , TO REQUEST THE CELL MODEM. ALLOW 8 WEEKS LEAD TIME BEFORE ANTICIPATED DEPLOYMENT.

PLANS PREPARED IN THE OFFICE OF:
Kimley»Horn
Intelligent Transportation Systems Section
750 N. Greenfield Pkwy, Garner, NC 27529
NC License #F-0102
421 Fayetteville Street, Suite 600
Raleigh, NC 27601
(919) 677-2000

 Final Phase

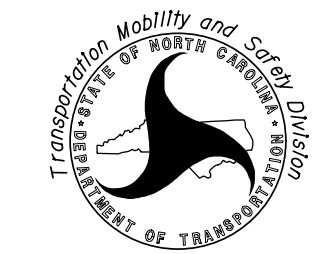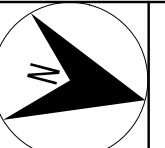 Prepared For: TRANSPORTATION Mobility and Safety Division NORTH CAROLINA DEPARTMENT OF TRANSPORTATION	D10-43_Huntersville			
	Spread Spectrum Wireless Radio Interconnect			
	Division 10 Mecklenburg County Huntersville			
	PLAN DATE: February 2026	REVIEWED BY: MC Burke		
PREPARED BY: SP Pennington	REVIEWED BY:	REVISIONS	INIT.	DATE
0SCALE N.T.S.				
 Molly Burke SEAL 058683 ENGINEER WOLLY C. BURKE		6/9/2026		
SIGNATURE		DATE		
SIG. INVENTORY NO.				

	DOCUMENT NOT CONSIDERED FINAL UNLESS ALL SIGNATURES COMPLETED
	SEAL
ville	
DATE	DocuSigned by  944E7BC0C0484E SIGNATURE
	6/9/2026 DATE
	SIG. INVENTORY NO.

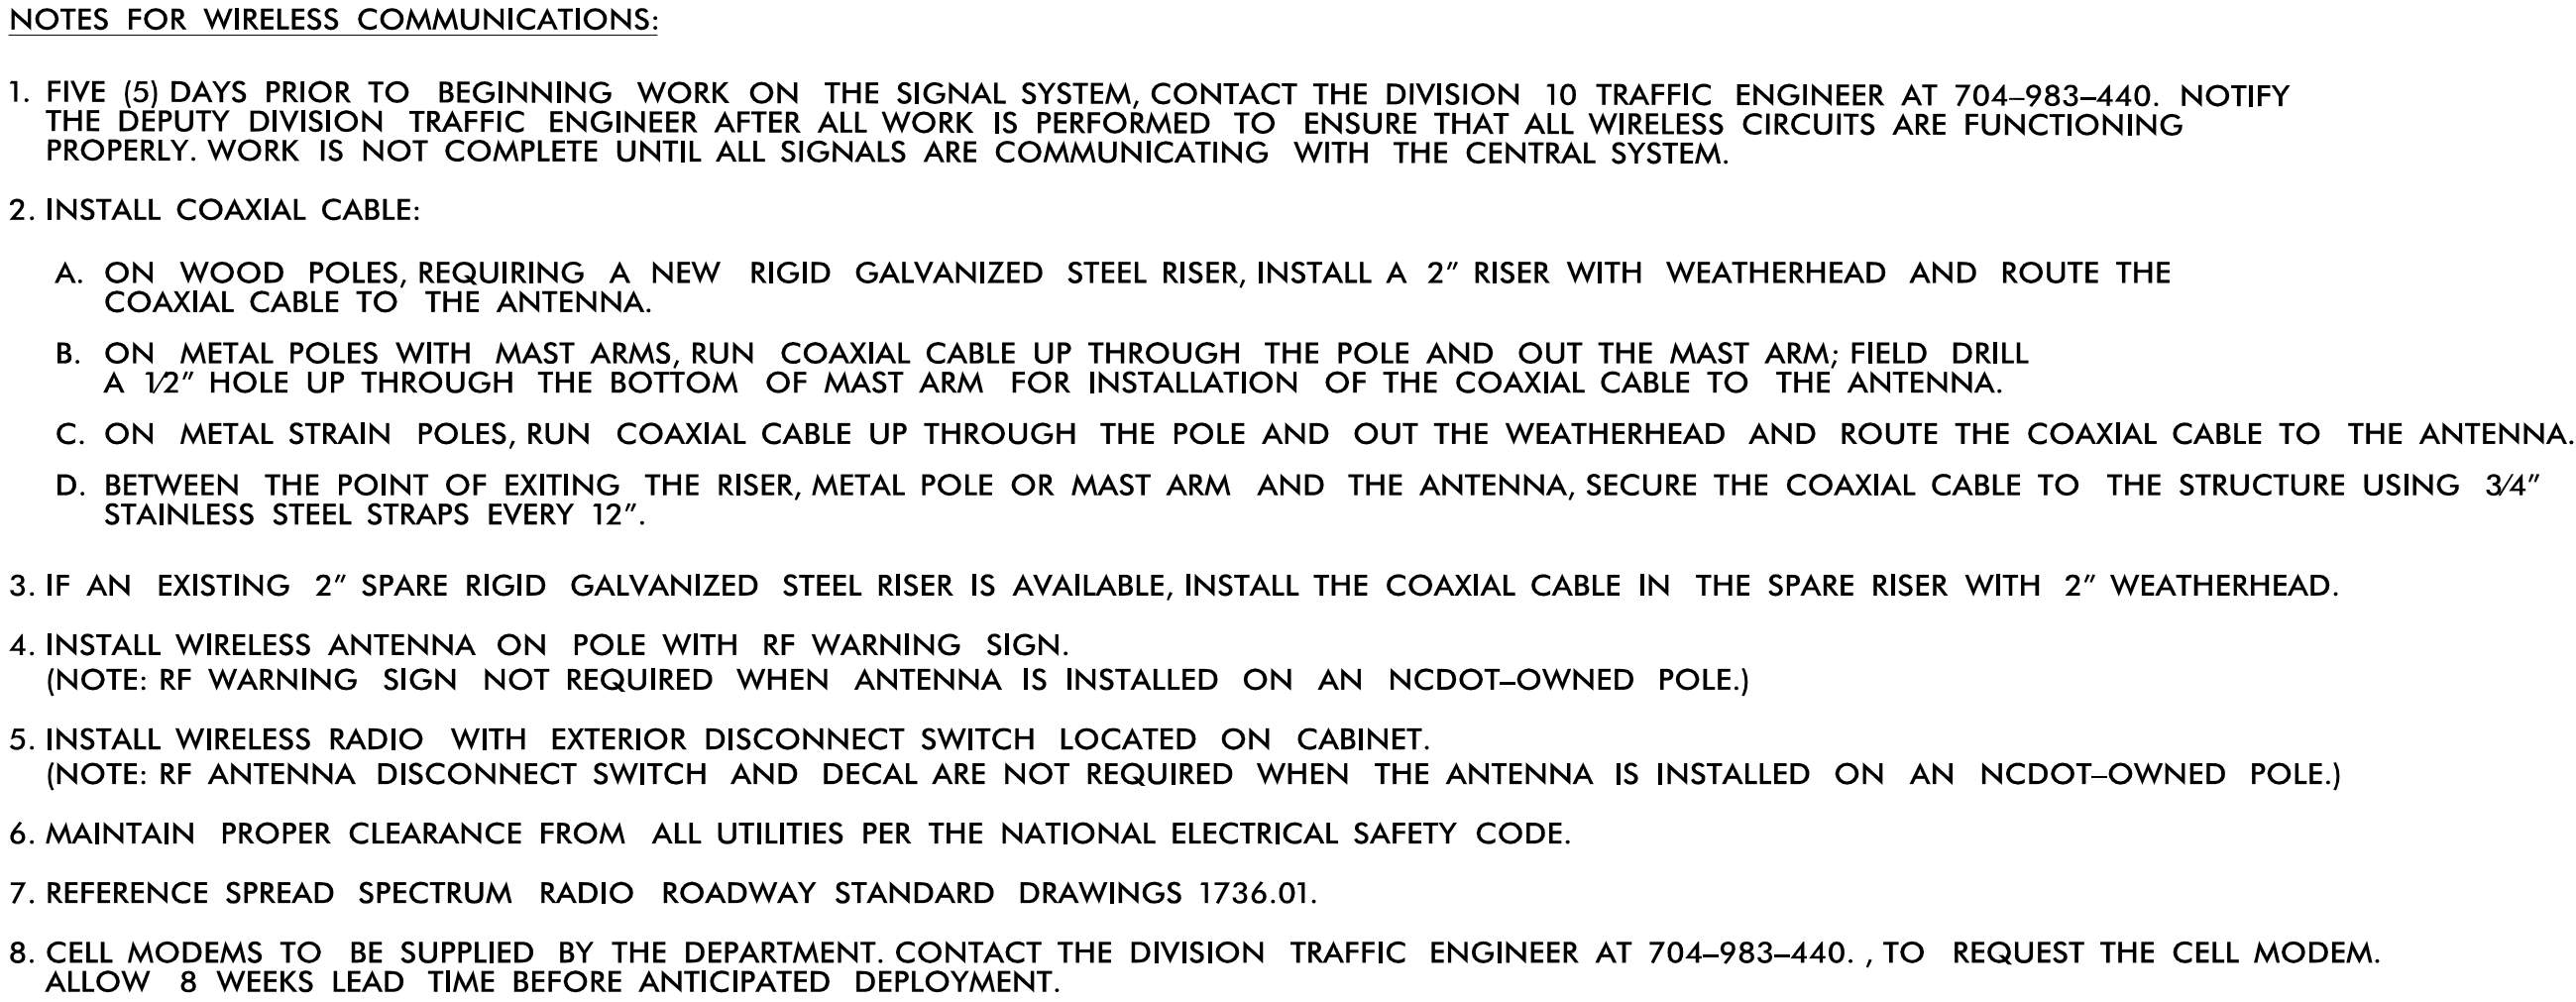

Final Phase

Prepared For:

Transportation Mobility and Safety Division
STATE OF NORTH CAROLINA
DEPARTMENT OF TRANSPORTATION

Intelligent Transportation Systems Section
750 N. Greenfield Pkwy, Garner, NC 27521

SCALE

0

N.T.S.

SEAL

NORTH CAROLINA
PROFESSIONAL
SEAL
058683
ENGINEER
MOLLY C. BURKE

DocuSigned by:
Molly Burke
954EF68C04C64E...
SIGNATURE

6/9/20
DA

SIG. [INVENTORY NO.]