
PROJECT REFERENCE NO. SHEET NO.

I-5986B SCP-7

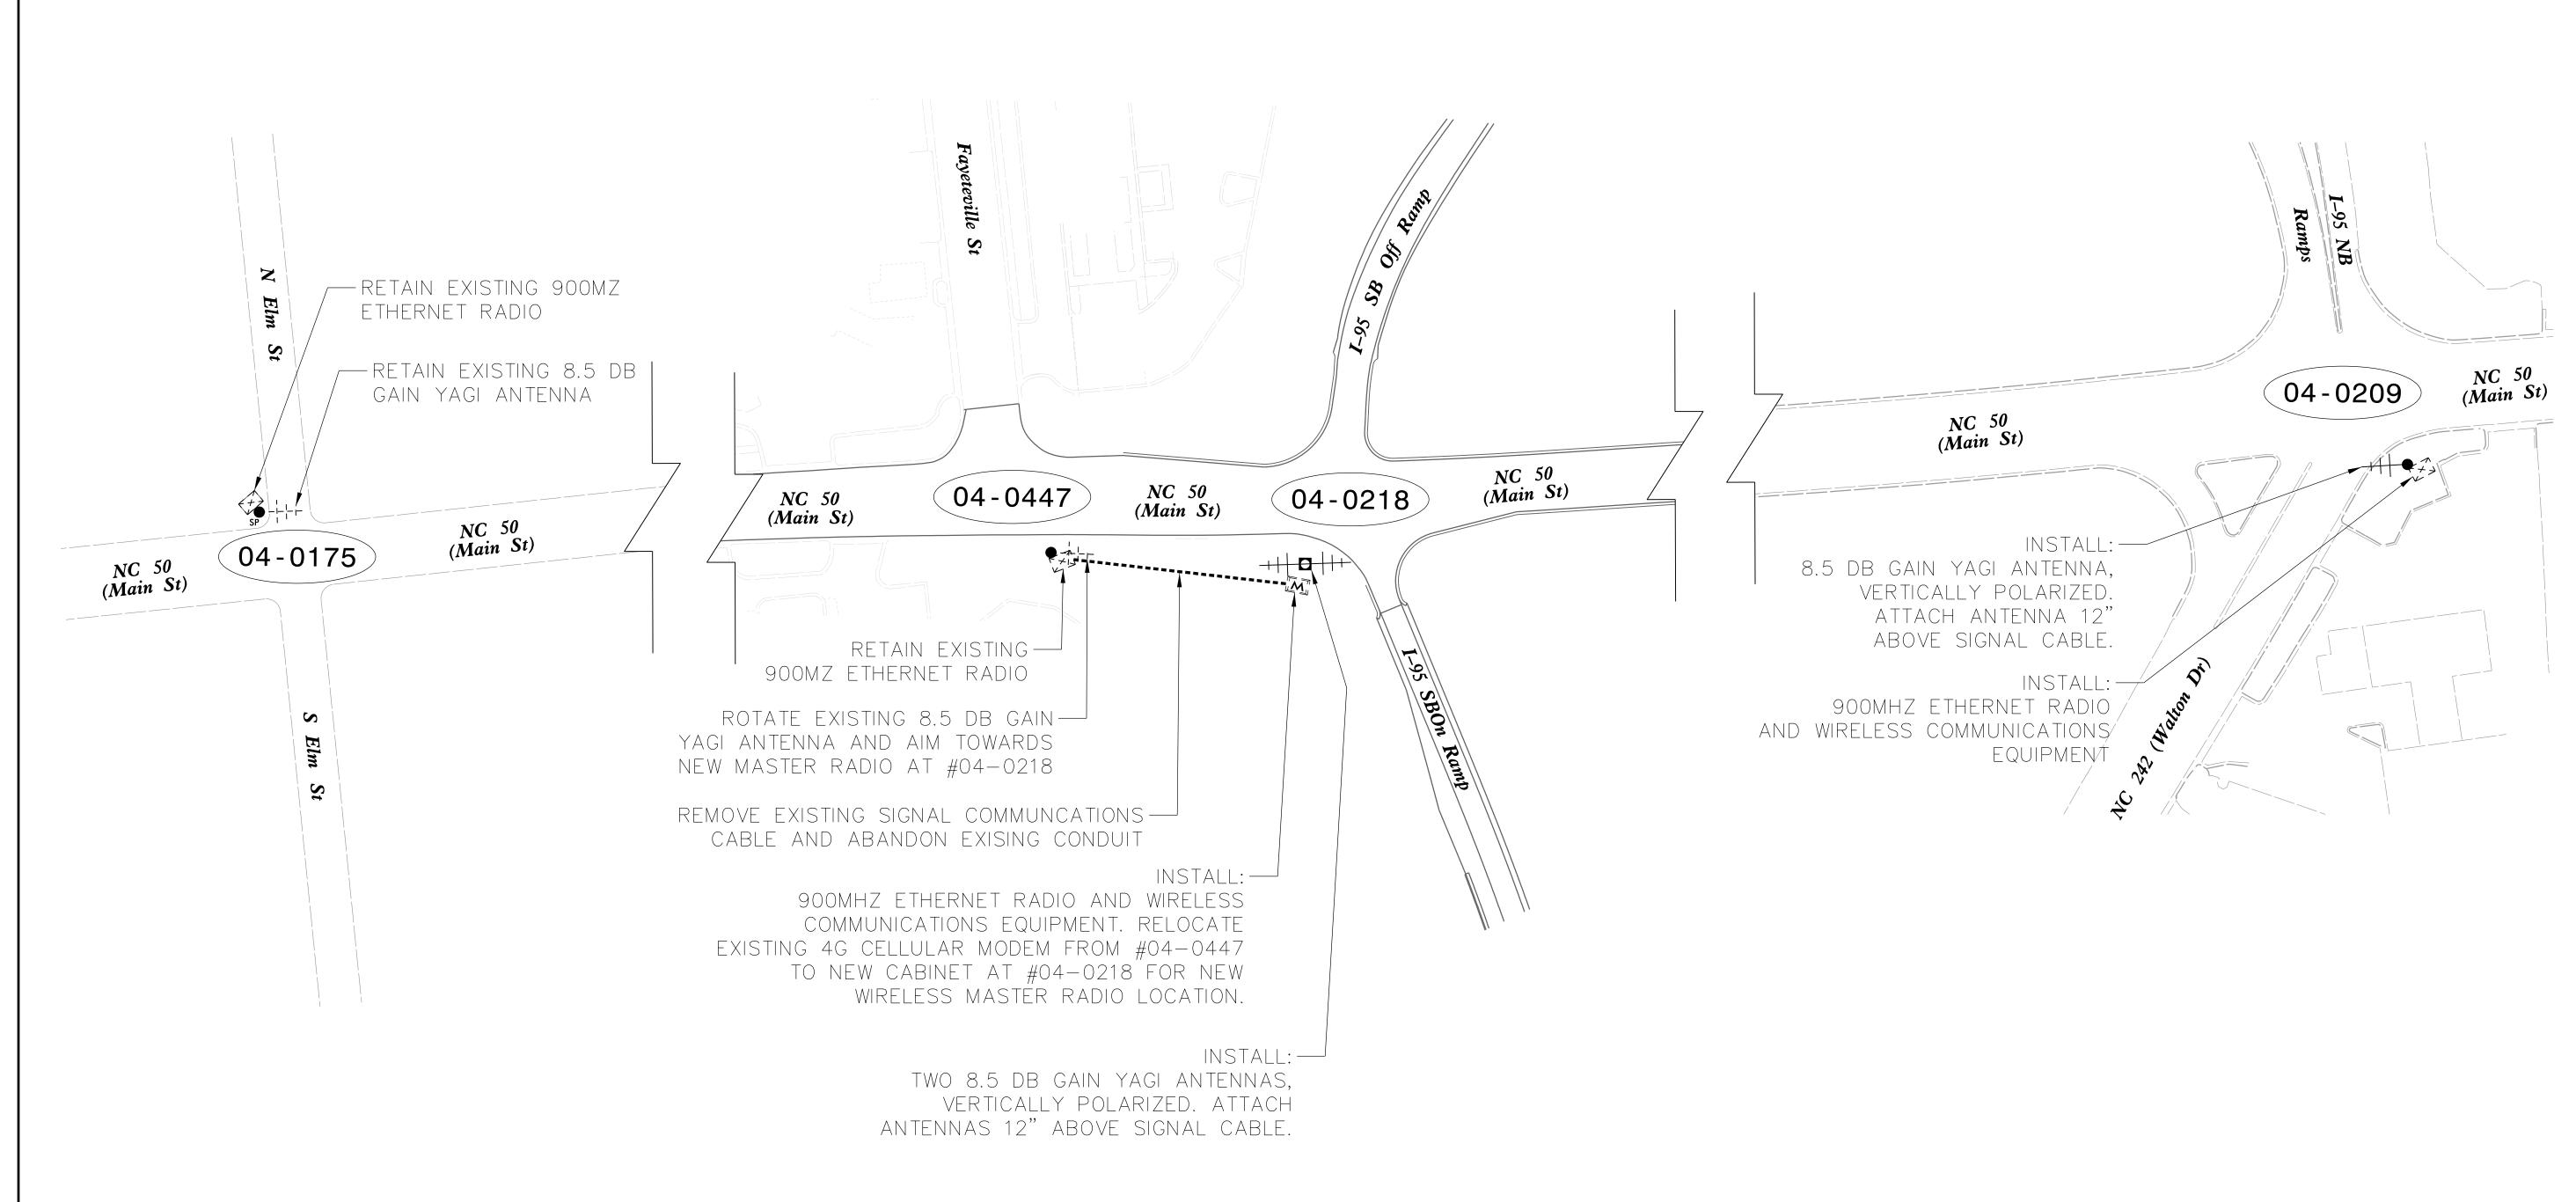

GENERAL NOTES:

1. FIVE (5) DAYS PRIOR TO BEGINNING WORK ON THE SIGNAL SYSTEM, CONTACT THE DIVISION 4 TRAFFIC ENGINEER AT (252) 640-6505 TO ARRANGE FOR THE DIVISION TRAFFIC ENGINEER TO PROGRAM THE NEW FIELD ETHERNET SWITCHES WITH THE NECESSARY NETWORK CONFIGURATION DATA, INCLUDING BUT NOT LIMITED TO: THE PROJECT IP ADDRESS, DEFAULT GATEWAY, SUBNET MASK AND VLAN ID INFORMATION. NOTIFY THE DIVISION TRAFFIC ENGINEER WHEN WORK IS PERFORMED TO ENSURE THAT ALL FIBER CIRCUITS ARE FUNCTIONING PROPERLY. WORK IS NOT COMPLETE UNTIL THE SIGNAL SYSTEM IS BACK UP AND OPERATIONAL.



INTERNATIONAL

8000 Regency Pkwy, Ste. 600, Cary, NC 27518
Phone: (919) 463-5490 · MBAKERINTL.COM
NC License No.: F-1084



SIGNAL COMMUNICATIONS PLANS SIGNAL SYSTEM #D04-20 BENSON TEMP 1 (TMP Phase I)

TEMP 1 (TMP Phase I)

DIVISION 04 JOHNSTON CO. BENSON

PLAN DATE: March 2021 REVIEWED BY: K M Cory

PREPARED BY: S Tamm REVIEWED BY:

SEAL
038970

NG INE

Column

C

DOCUMENT NOT CONSIDERED FINAL UNLESS ALL SIGNATURES COMPLETED