
Install CCTV POE Injector

US 301 (N Clinton Ave)

NOTES:

DocuSign Envelope ID: 8837B788-843C-49E5-AA40-6FF8FF151D6A

- 1) MAINTAIN A MINIMUM OF SIX (6) FEET FROM THE EDGE OF PAVEMENT WHEN TRENCHING PARALLEL TO THE ROADWAY.
- 2) CONTACT THE DIVISION TRAFFIC ENGINEER AT (910) 364–0606 TO CONFIRM THE LOCATION OF THE CCTV CAMERA.
- 3) DO NOT INSTALL CONDUIT OR JUNCTION BOXES UNTIL THE LOCATION OF THE CCTV CAMERA HAS BEEN CONFIRMED BY THE DIVISION ITS ENGINEER.
- 4) INSTALL THE CCTV WOOD POLE AND CABINET ASSEMBLY A MINIMUM OF 30' FROM THE ROADWAY EDGE OF TRAVEL OR INSTALL GUARDRAIL AS NEEDED.
- 5) MOUNT THE CCTV CAMERA 5' BELOW THE TOP OF THE POLE.
 6) IT IS THE CONTRACTOR'S RESPONSIBILITY TO OBTAIN THE AVAILABLE FAULT CURRENT INFORMATION FROM THE POWER COMPANY FOR THE REQUIRED ELECTRICAL SERVICE AND PLACE A "FAULT CURRENT" STICKER INSIDE THE SERVICE DISCONNECT PANEL WITH THE DATE AND AVAILABLE FAULT CURRENT ON THE STICKER.
- 7) AT THE DATE AND AVAILABLE FAULT CORRENT ON THE STICKER. GUARDRAIL, POLE INSTALLATION AND DMS CONSTRUCTION WORK HAS BEEN PERFORMED.
- 8) RETURN EXISTING CCTV EQUIPMENT TO THE NCDOT DIVISION 6 TRAFFIC SERVICES OFFICE AT 558 GILLESPIE STREET, FAYETTEVILLE, NC 28301. CONTACT FRANK WEST, IR AT (910) 364–0606 TWO WEEKS IN ADVANCE TO COORDINATE DELIVERY
- JR. AT (910) 364–0606 TWO WEEKS IN ADVANCE TO COORDINATE DELIVERY. 9) NCDOT DIVISION 6 WILL FURNISH THE CCTV AND DMS CELL MODEMS. CONTACT
- THE ENGINEER SIX (6) WEEKS PRIOR TO BEGINNING WORK. 10) REFER TO THE TRANSPORTATION MANAGEMENT PLAN FOR LANE CLOSURE TIME RESTRICTIONS.

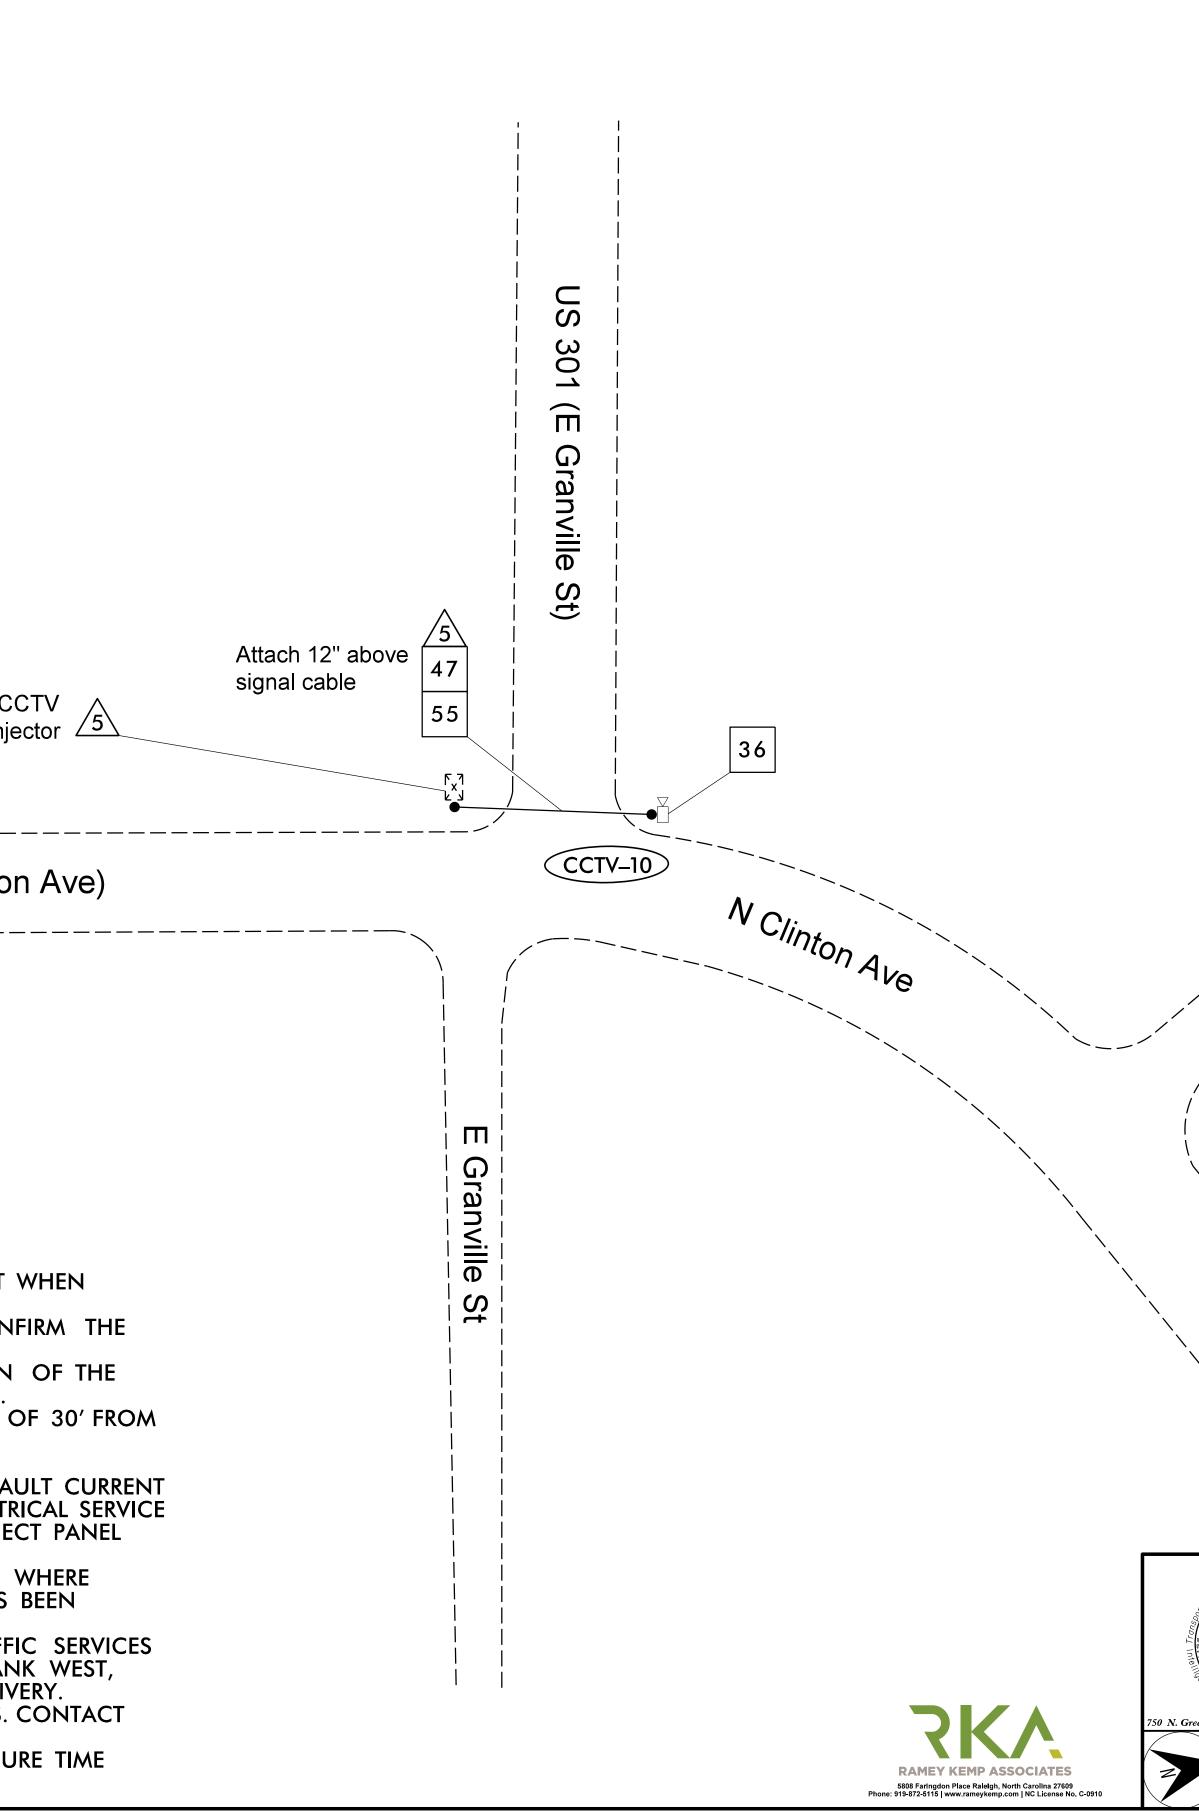

PROJECT REFERENCE NO.	SHEET NO.
I-5986B	ITS-11

		N Clint	on Ave			
Catolina D						
						DOCUMENT NOT CONSIDERED FINAL UNLESS ALL SIGNATURES COMPLETED
Prepared For:	US 301 at Carolina Dr CCTV PLAN DATE: March 2021 REVIEWED BY: WJ Hamilton				SEAL SEAL SEAL 32396 MGINEER	
Screenfield Pkwy., Garner, NC 27529 SCALE 0 40	PREPARED BY:	A. Andrews REVISIONS	RKA PROJ. NO.:	18132 INIT.	(040) DATE	Docusignedatory, J. HAMM William J. Hamilton ADD560DZ04648484 SIGNATURE DATE