
PROJECT REFERENCE NO. SHEET NO. U-5738 SCP 4

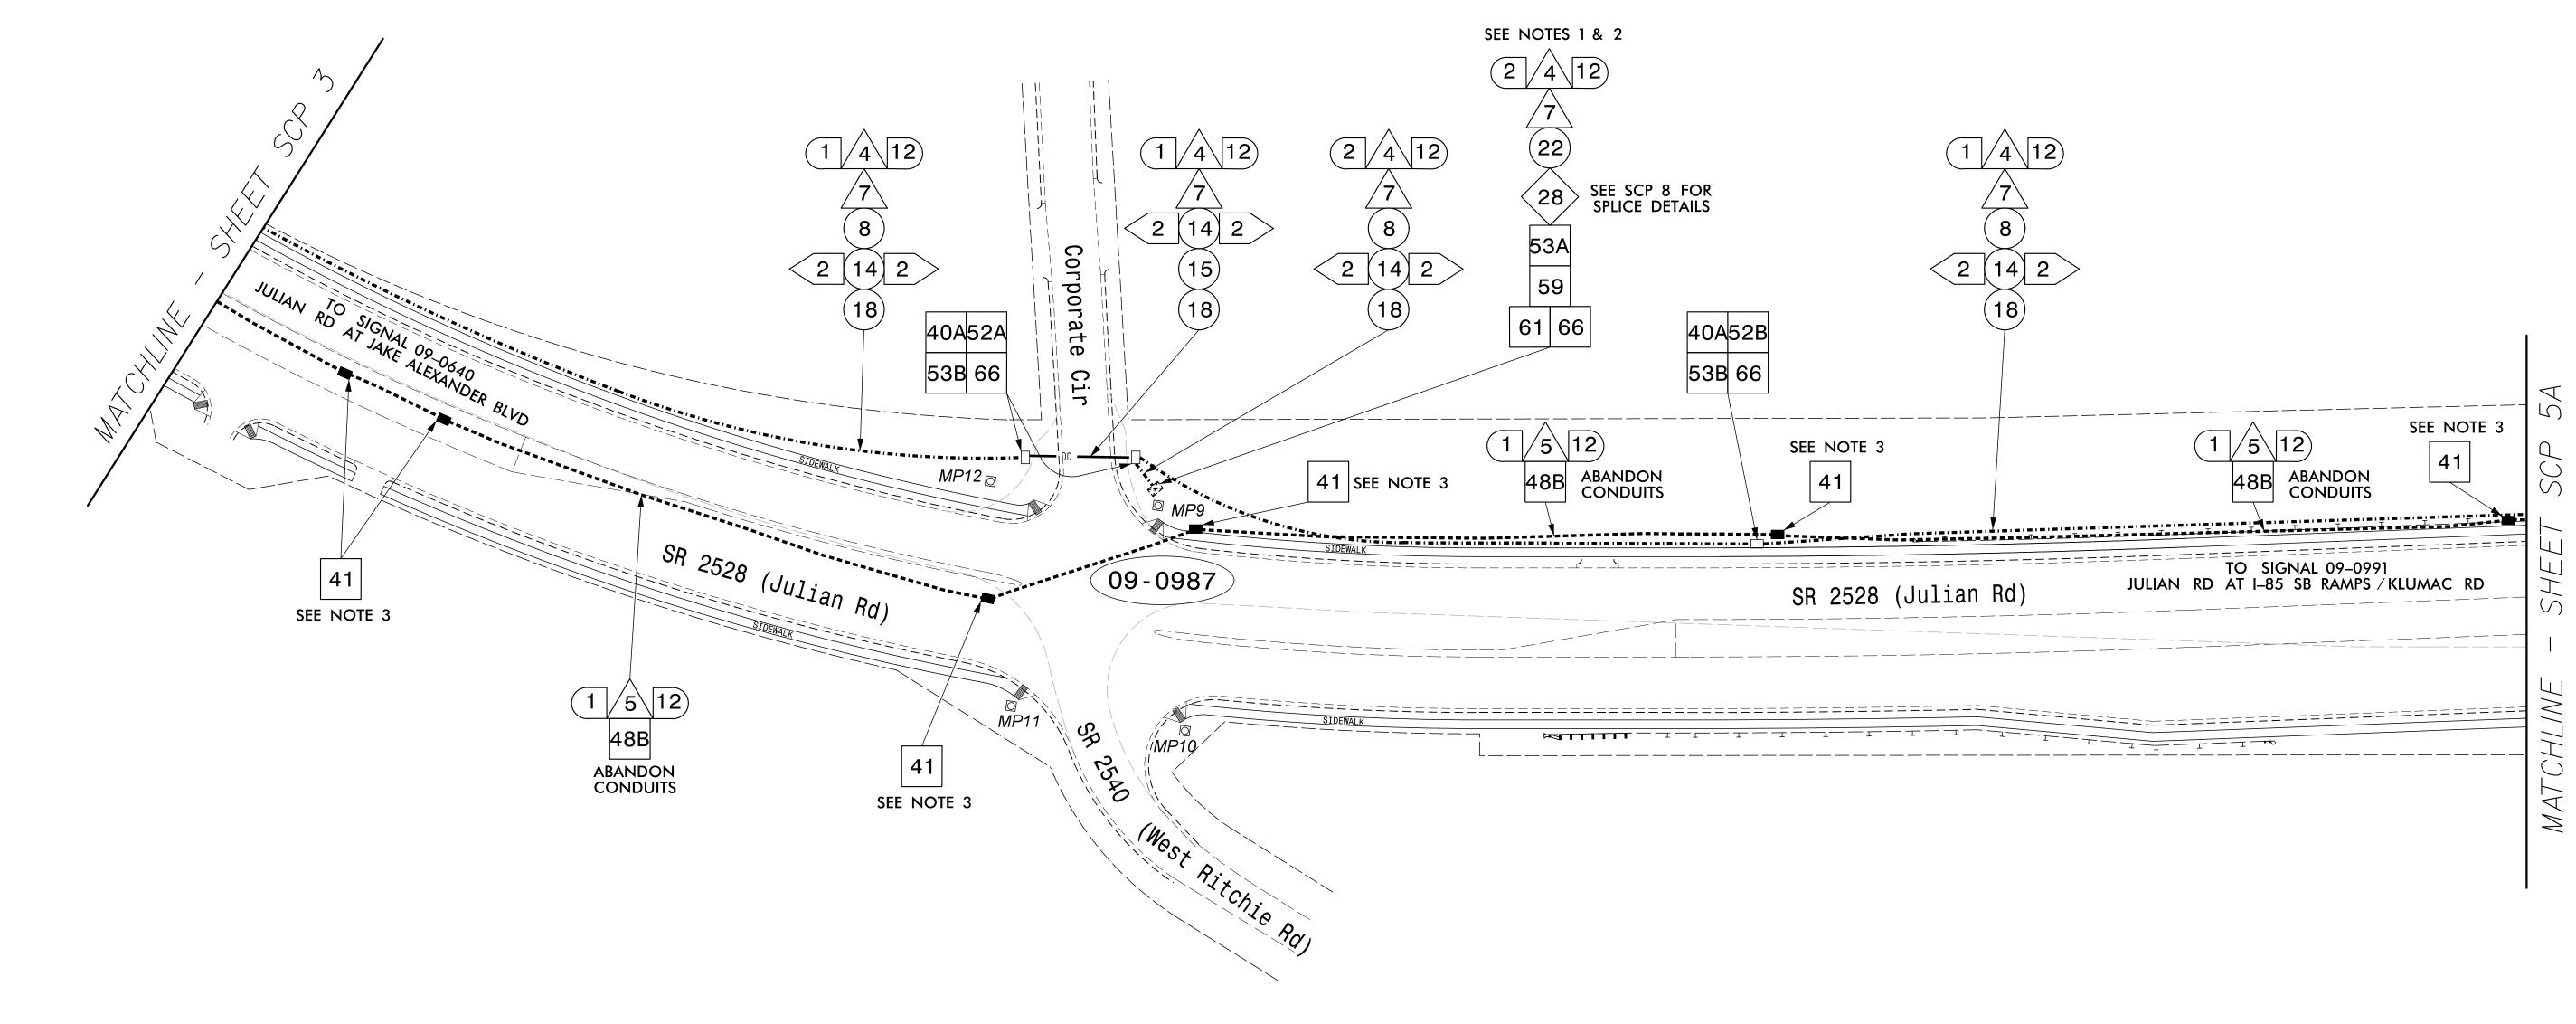

NOTES:

- 1. TWO (2) WEEKS PRIOR TO BEGINNING WORK ON THE SIGNAL SYSTEM, CONTACT THE NCDOT DIVISION TRAFFIC ENGINEER J. P. COUCH AT 336–747–7800 AND THE CITY OF SALISBURY TRAFFIC ENGINEERING COORDINATOR VICKIE EDDLEMAN AT 704–638–5200 TO REQUEST ASSISTANCE IN PROGRAMMING THE NEW ETHERNET EDGE SWITCH WITH THE NECESSARY NETWORK CONFIGURATION.
- 2. NOTIFY THE NCDOT DIVISION TRAFFIC ENGINEER J. P. COUCH AT 336–747–7800, REGIONAL ITS ENGINEER AT 336–315–7080, AND THE CITY OF SALISBURY TRAFFIC ENGINEERING COORDINATOR VICKIE EDDLEMAN AT 704–638–5200
 TWO (2) WEEKS PRIOR TO BEGINNING WORK ON THE SIGNAL SYSTEM COMMUNICATIONS AND ITS FIBER OPTIC CABLES. NOTIFY THE NCDOT DIVISION TRAFFIC ENGINEER, REGIONAL ITS ENGINEER AND THE CITY'S TRAFFIC ENGINEERING COORDINATOR
 AFTER ALL WORK IS PERFORMED TO ENSURE THAT ALL FIBER CIRCUITS ARE FUNCTIONING PROPERLY. WORK IS NOT COMPLETE UNTIL THE SIGNAL SYSTEM AND THE ITS SYSTEM ARE BOTH BACK UP AND OPERATIONAL (SEE ICT).
- 3. REMOVE EXISTING JUNCTION BOXES AND BACKFILL WITH AN APPROVED MATERIAL.

Accelerate Engineering, PLLC
875 Walnut Street, Suite 316
Cary, NC 27511
Tel: 919.263.5678 Fax: 919.263.5687
NC License No. P-1442



Signal Communications Plan

Division 9 Rowan County Salisbury

PLAN DATE: November 2021 REVIEWED BY: B. Phillips

PREPARED BY: 7 "Gavin" Teng REVIEWED BY:

750 N.Greenfleld Pkwy.Garner.NC 27529 PREPARED BY: Z. "Gavin" Teng REVIEWED BY:

SCALE

O

50

DOCUMENT NOT CONSIDERED

FINAL UNLESS ALL SIGNATURES COMPLETED

SEAL