DocuSign Envelope ID: 4AFEED42-4794-457E-984A-E72778C38165

Kimley» Horn

421 FAYETTEVILLE STREET, SUITE 600 RALEIGH, NC 27601 PROJECT REFERENCE NO.

U-5606


SHEET TITLE: STREET LIGHTING PLAN

CARO

SEAL

DOCUMENT NOT CONSIDERED FINAL

027615

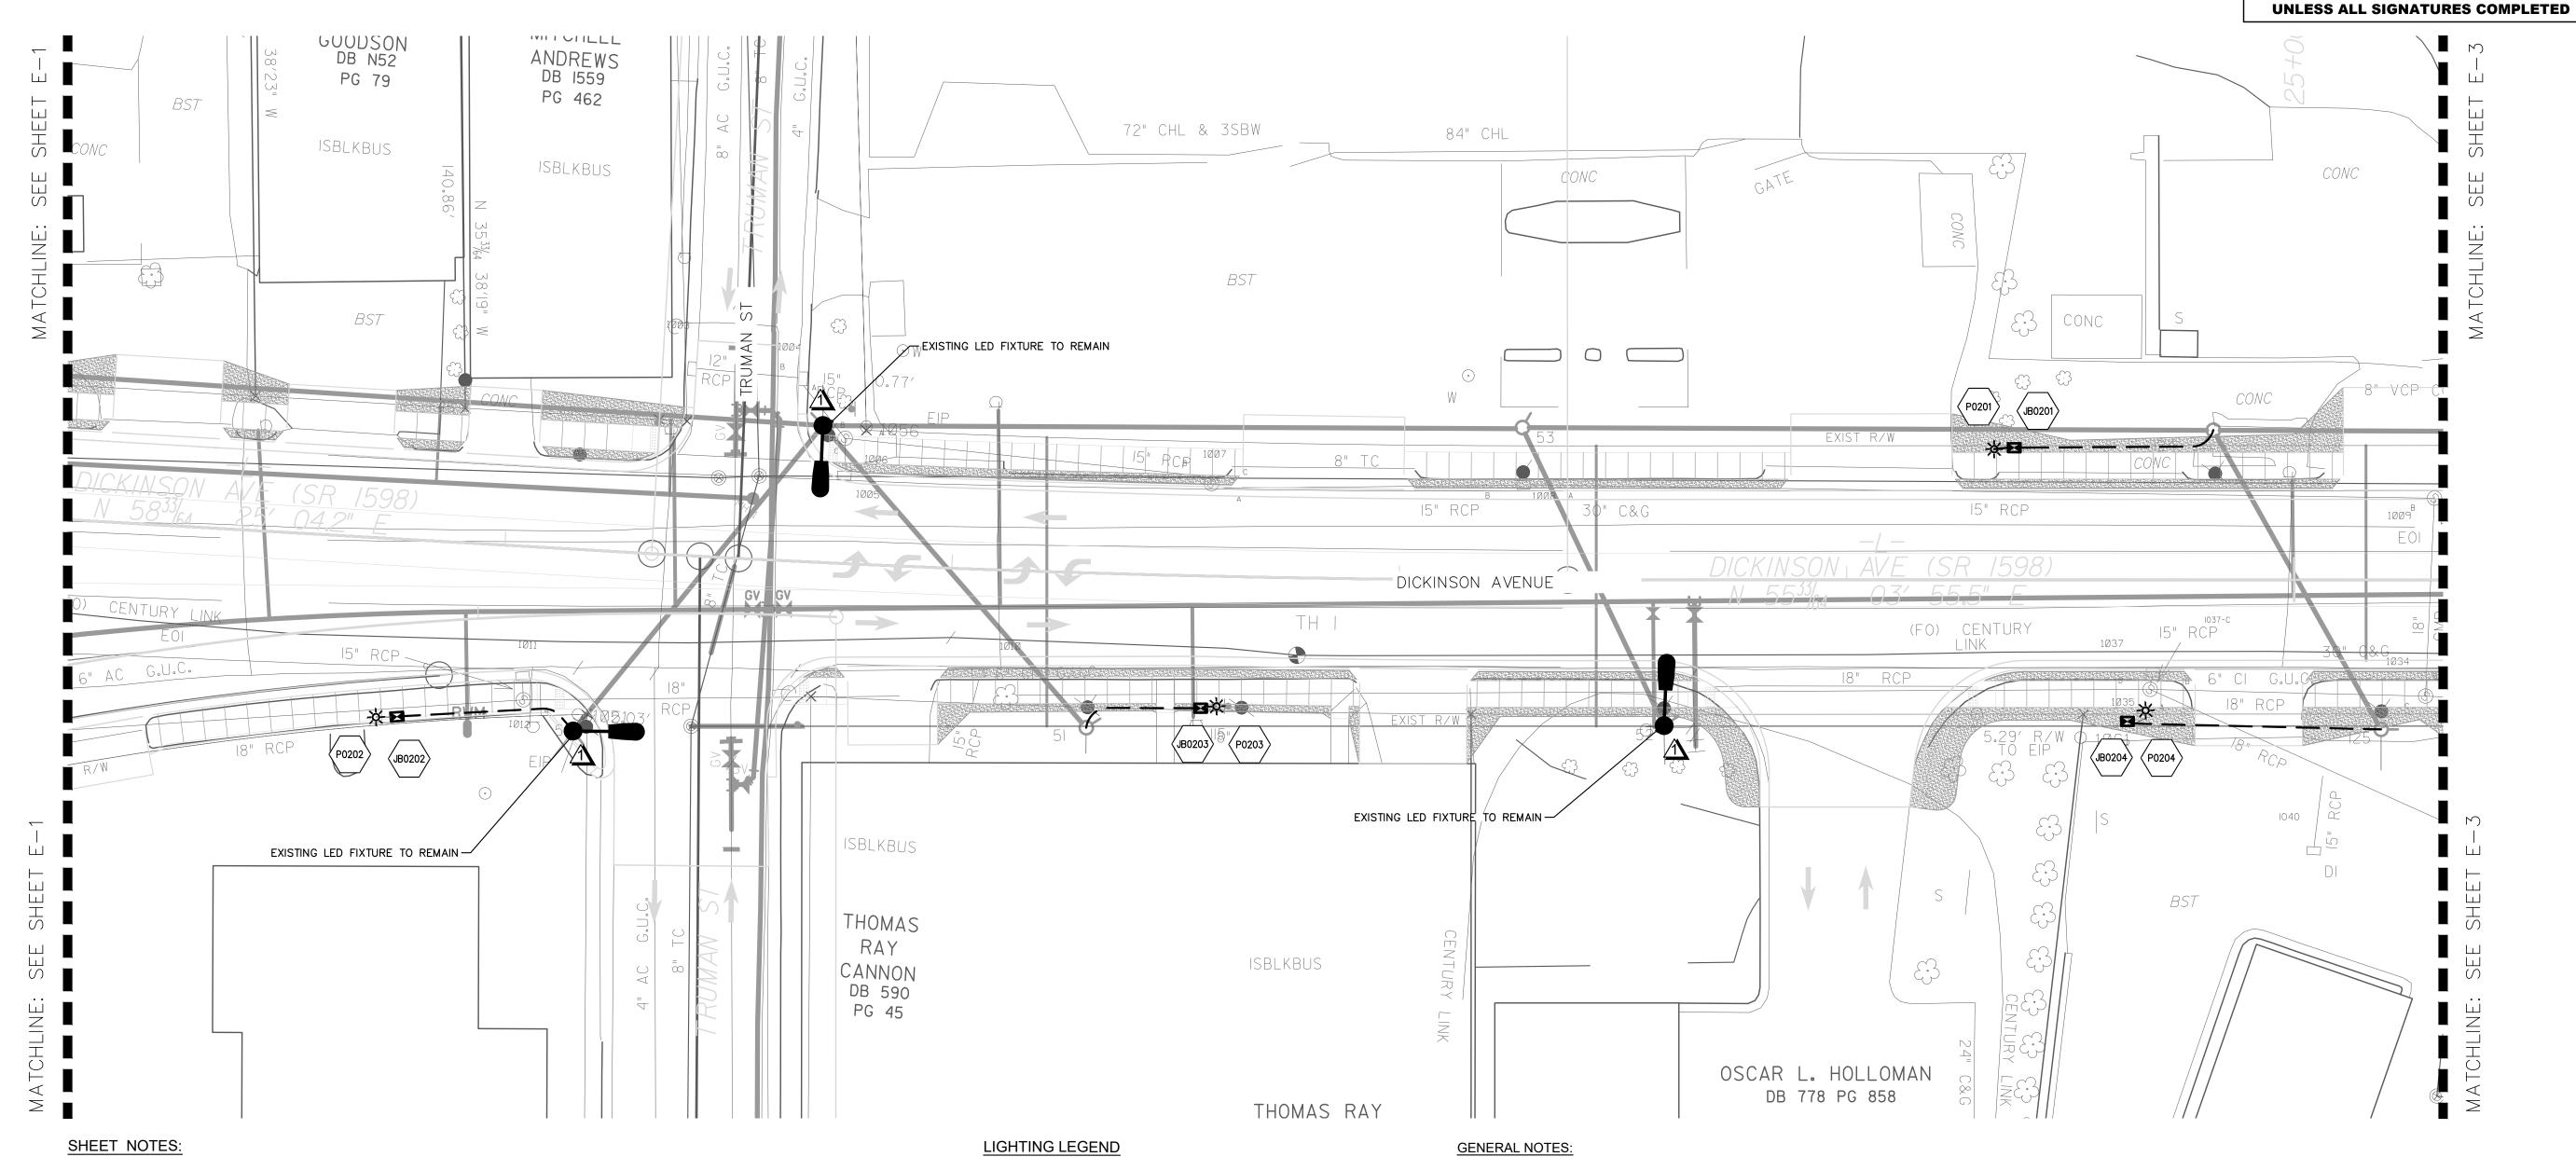


LIGHTING PLAN ASSUMES UTILITY RELOCATION HAS BEEN COMPLETED.

110W GUC LED COBRA HEAD FIXTURE

W/LED LANTERN FIXTURE

18" x 24" x 18" TYPE PC

 100W GUC BLACK DECORATIVE POLE







LIGHT FIXTURE, JUNCTION BOX ID

JUNCTION BOX



1. THE STANDARD SPECIFICATIONS FOR ROADS AND STRUCTURES DATED JANUARY 2018 OF THE STATE OF NORTH CAROLINA DEPARTMENT OF TRANSPORTATION AND SUPPLEMENTAL

SPECIFICATIONS LISTED IN THE BID DOCUMENTS SHALL GOVERN THIS IMPROVEMENT.

- 2. CONDUIT PATHS ARE SCHEMATIC IN NATURE. CONTRACTOR SHALL ROUTE UNDERGROUND RACEWAYS BEHIND CURB AND TO AVOID CONFLICTS WITH EXISTING AND/OR PROPOSED VALVES, METERS, CATCH BASINS, STREET TREES, ETC. CONTRACTOR TO MINIMIZE DISTURBANCE TO ROADWAY DURING INSTALLATION OF RACEWAYS WHEN NOT CROSSING DRIVES.
- CONTRACTOR IS RESPONSIBLE FOR REPAIRING OR REPLACING TO THE SATISFACTION OF THE ENGINEER. ALL DAMAGE TO CURBS, UNDERDRAINS, DRIVES, BUILDINGS, ETC. CAUSED BY THE INSTALLATION OF NEW WORK.
- 4. CONTRACTOR TO STUB CONDUIT UP APPROXIMATELY 3' IN FRONT OR BACK OF THE LIGHT POLE LOCATIONS TO PROVIDE ADEQUATE SPACE FOR JUNCTION BOXES. LIGHT FIXTURES TO BE INSTALLED BY GREENVILLE UTILITIES (GUC) AT A LATER DATE.
- 5. UNDERGROUND CONDUITS ARE 2" PVC CONDUIT. INSTALL PULL LINE INSIDE CONDUIT.
- 6. JUNCTION BOXES ARE 18" (W) x 24" (L) x 18" (D).
- 7. LIGHTING LAYOUT SHOWN ASSUMES UTILITY RELOCATION COMPLETE.

