
DocuSign Envelope ID: 4AFEED42-4794-457E-984A-E72778C38165

LIGHTING PLAN ASSUMES UTILITY RELOCATION HAS BEEN COMPLETED.

421 FAYETTEVILLE STREET, SUITE 600 RALEIGH, NC 27601

PROJECT REFERENCE NO. SHEET NO. E-7 U-5606 SHEET TITLE: STREET LIGHTING PLAN

DOCUMENT NOT CONSIDERED FINAL UNLESS ALL SIGNATURES COMPLETED

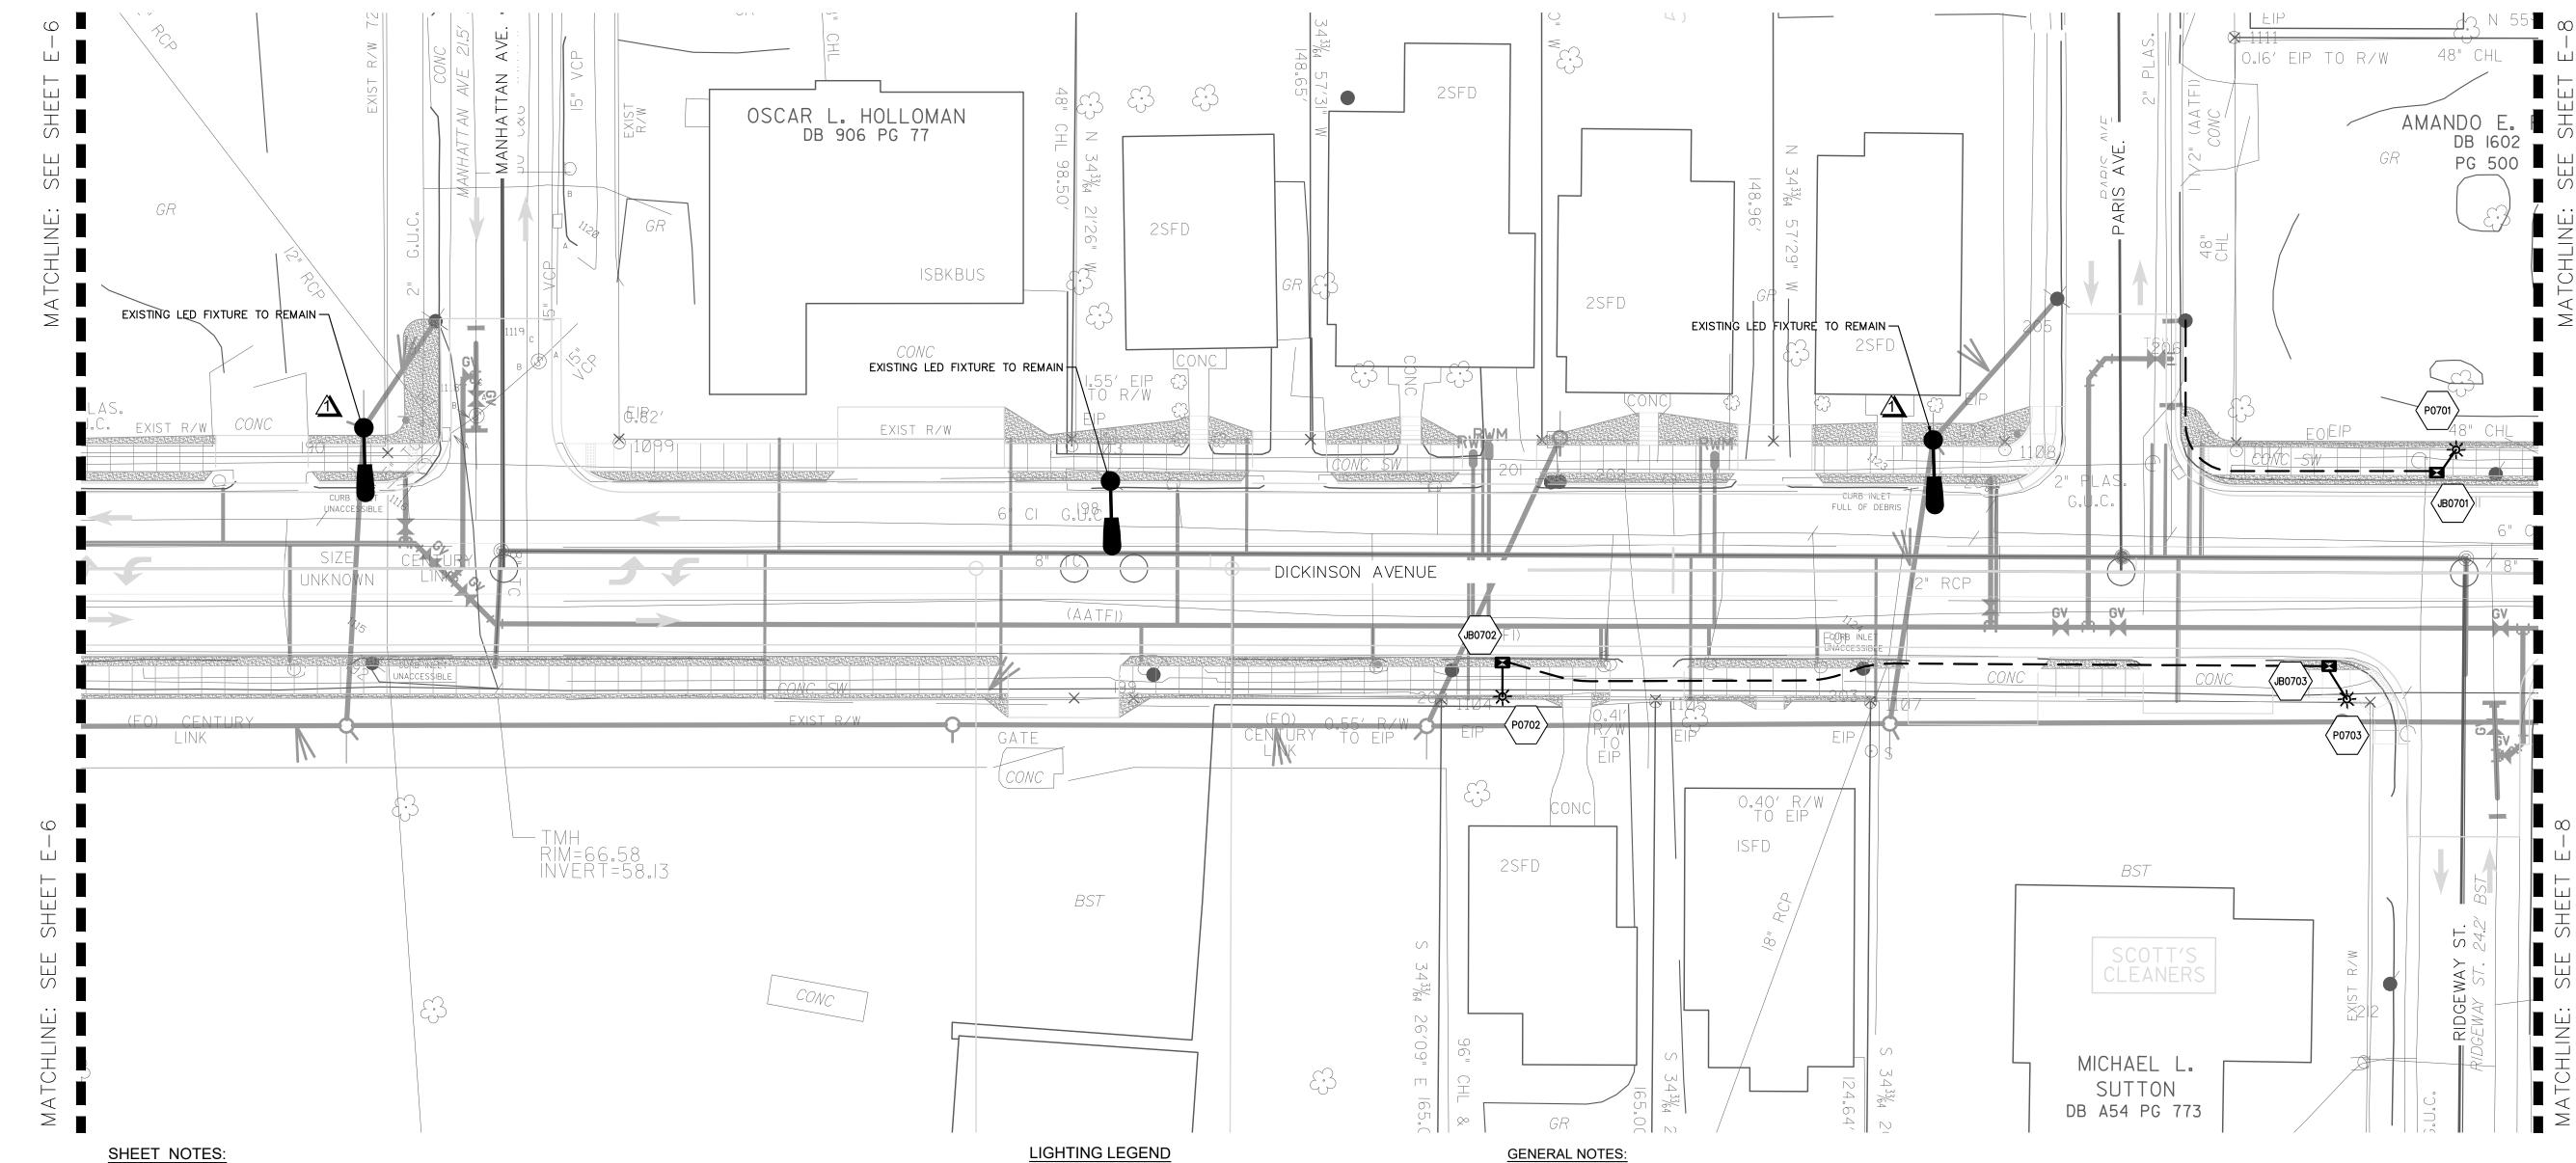

\_ ELECTRICAL CONDUIT

ELECTRICAL SERVICE

DUPLEX RECEPTACLE

**ASSEMBLY** 

(2" UNLESS OTHERWISE NOTED)

110W GUC LED COBRA HEAD FIXTURE

W/LED LANTERN FIXTURE

18" x 24" x 18" TYPE PC

JUNCTION BOX

LIGHT FIXTURE,

JUNCTION BOX ID

100W GUC BLACK DECORATIVE POLE

- GENERAL NOTES:
- 1. THE STANDARD SPECIFICATIONS FOR ROADS AND STRUCTURES DATED JANUARY 2018 OF THE STATE OF NORTH CAROLINA DEPARTMENT OF TRANSPORTATION AND SUPPLEMENTAL
- SPECIFICATIONS LISTED IN THE BID DOCUMENTS SHALL GOVERN THIS IMPROVEMENT. CONDUIT PATHS ARE SCHEMATIC IN NATURE. CONTRACTOR SHALL ROUTE UNDERGROUND RACEWAYS BEHIND CURB AND TO AVOID CONFLICTS WITH EXISTING AND/OR PROPOSED VALVES, METERS, CATCH BASINS, STREET TREES, ETC. CONTRACTOR TO MINIMIZE DISTURBANCE TO ROADWAY DURING INSTALLATION OF RACEWAYS WHEN NOT CROSSING
- 3. CONTRACTOR IS RESPONSIBLE FOR REPAIRING OR REPLACING TO THE SATISFACTION OF THE ENGINEER. ALL DAMAGE TO CURBS, UNDERDRAINS, DRIVES, BUILDINGS, ETC. CAUSED BY THE INSTALLATION OF NEW WORK.
- 4. CONTRACTOR TO STUB CONDUIT UP APPROXIMATELY 3' IN FRONT OR BACK OF THE LIGHT POLE LOCATIONS TO PROVIDE ADEQUATE SPACE FOR JUNCTION BOXES. LIGHT FIXTURES TO
- BE INSTALLED BY GREENVILLE UTILITIES (GUC) AT A LATER DATE. 5. UNDERGROUND CONDUITS ARE 2" PVC CONDUIT. INSTALL PULL LINE INSIDE CONDUIT.
- 6. JUNCTION BOXES ARE 18" (W) x 24" (L) x 18" (D).
- 7. LIGHTING LAYOUT SHOWN ASSUMES UTILITY RELOCATION COMPLETE.

