

09/08/99

Project No.	Sheet No.
U-4753	Sig. 1.0



STATE OF NORTH CAROLINA
DEPARTMENT OF TRANSPORTATION

TRAFFIC SIGNAL AND SIGNAL COMMUNICATIONS PLAN
WAYNE COUNTY

LOCATION: SR 1556 (WAYNE MEMORIAL DR.) FROM SOUTH-
WEST OF SR 1003 (NEW HOPE RD.) TO I-42 (FORMERLY US 70)

TYPE OF WORK: TRAFFIC SIGNALS AND TRAFFIC SIGNAL COMMUNICATIONS

TIP PROJECT: U-4753

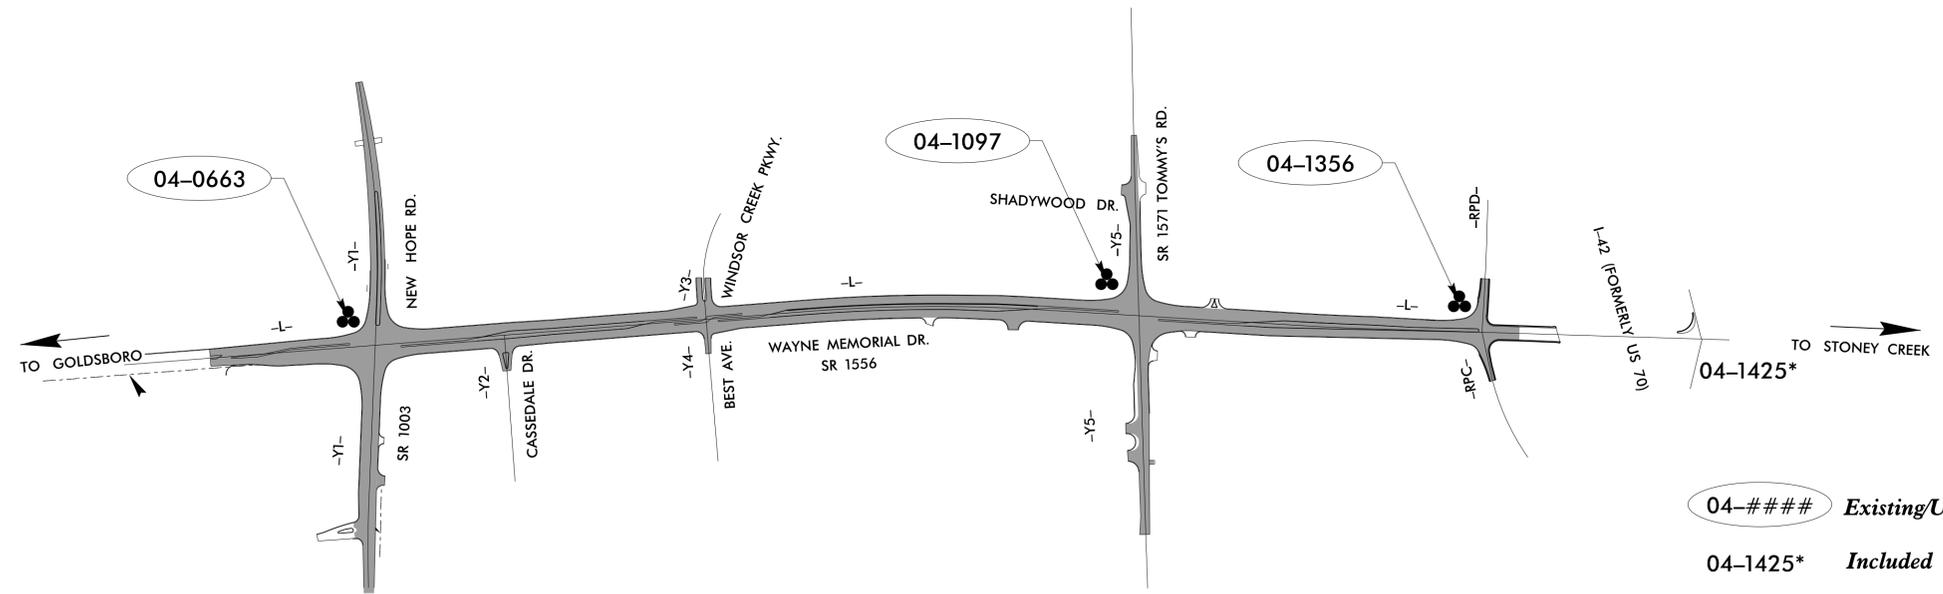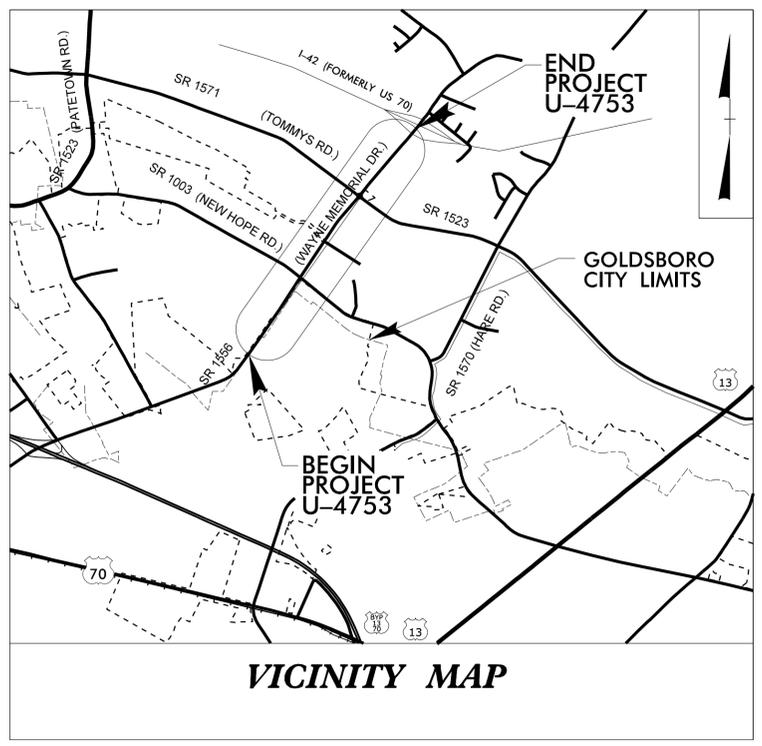

04-#### Existing/Upgraded Signal
04-1425* Included with SCP only

CONTRACT:

INDEX OF PLANS		
SHEET NUMBER	SIGNAL INV. NUMBER	LOCATION /DESCRIPTION
Sig. 1.0	-	Title Sheet
Sig. 2.0 - Sig. 3.3	04-0663	SR 1556 (Wayne Memorial Drive) at SR 1003 (New Hope Road)
Sig. 4.0 - Sig. 5.4	04-1097	SR 1556 (Wayne Memorial Drive) at SR 1571 (Tommy's Road)
Sig. 6.0 - Sig. 7.3	04-1356	SR 1556 (Wayne Memorial Drive) at I-42 (Old US 70 Pyp) EB Ramps
MIA - M9	-	NCDOT 2024 Metal Pole Standard Drawing Sheets
SCPI - SCP9	-	Signal Communications Plans

TRANSYSTEMS

1 Glenwood Avenue
Raleigh, NC 27603
Tel: 919.789.9977
Fax: 919.789.9591
License: F-0453

G.G. Murr, Jr., P.E. - Signals Project Engineer
J.T. Rowe, Jr. P.E. - Electrical Engineer
N. Degbotse, EI - Signal Design Engineer

Refer to "Roadway Standard Drawings
NCDOT" dated January 2024 and
Standard Specifications for Roads
and Structures" dated January 2024

INTELLIGENT TRANSPORTATION AND SIGNALS UNIT

Contacts:

Zachary M. Little, P.E. - Eastern Region Signals Project Engineer
Keith M. Mims, P.E. - Signal Equipment Design Engineer
Gregg Green - Signal Communications Project Engineer

Prepared for the Office of:
DIVISION OF HIGHWAYS
TRANSPORTATION MOBILITY AND SAFETY
DIVISION
Transportation Systems Management & Operations Unit



9/5/2025
U-4753-sig-1-sh-2022xxxx.dgn
USER:deTouff